



PRODUCED BY AN AUTODESK EDUCATIONAL PRODUCT

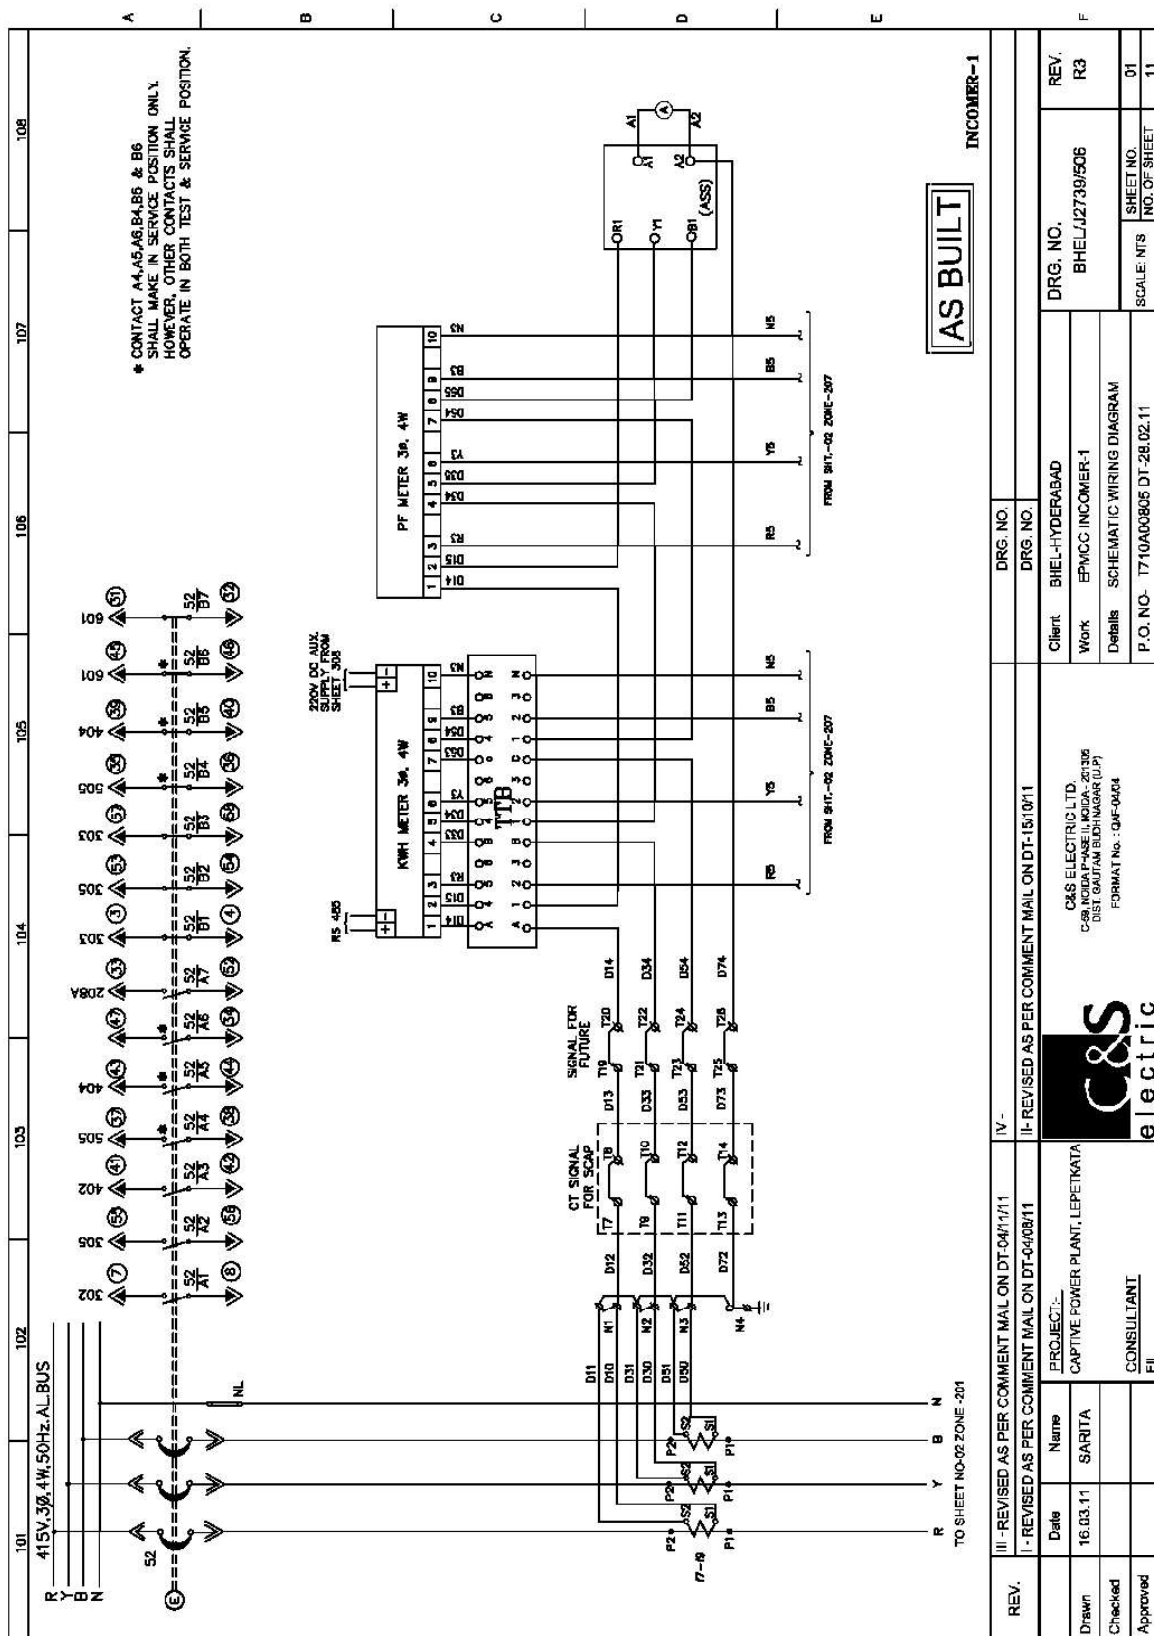


The contents of this Drawing are the sole property of C&S ELECTRIC LTD. and they should neither be copied nor given to a third person without the prior permission of Company

PRODUCED BY AN AUTODESK EDUCATIONAL PRODUCT

 PRODUCED BY AN AUTODESK EDUCATIONAL PRODUCT



PRODUCED BY AN AUTODESK EDUCATIONAL PRODUCT

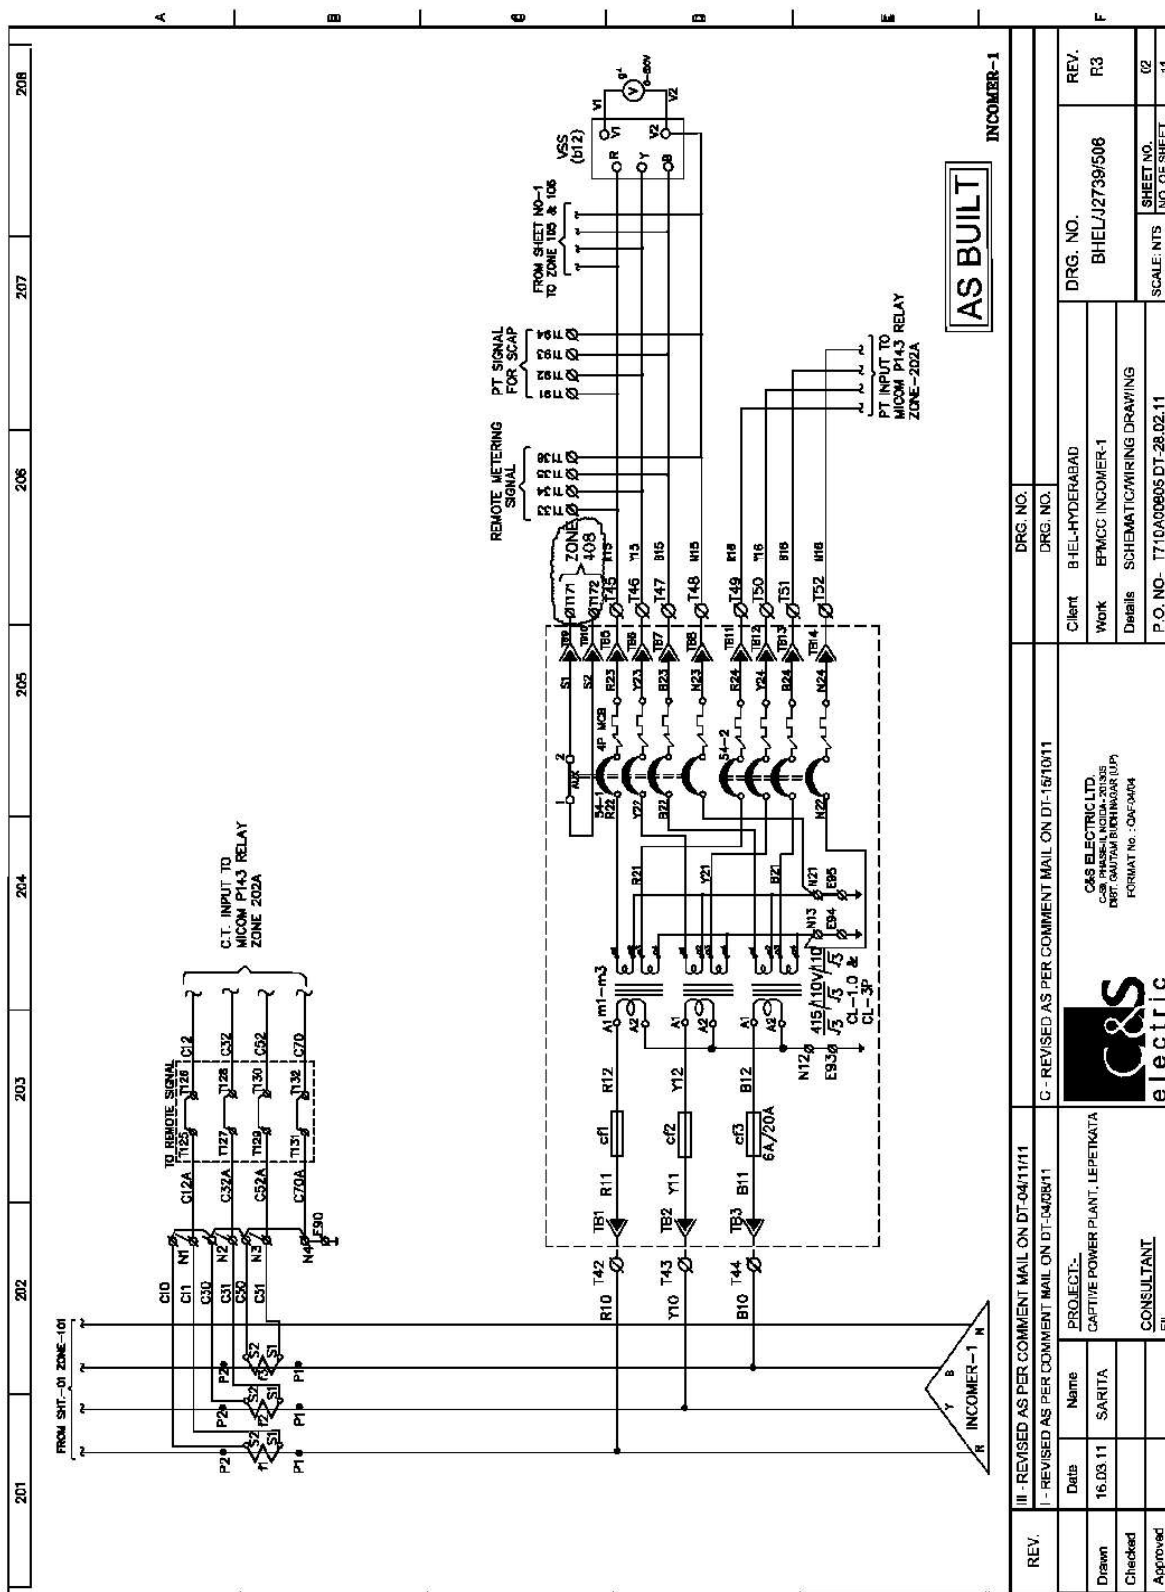

The contents of this Drawing are the sole property of
CONTROLS & SWITCHGEAR COMPANY LTD.
and they should neither be copied nor given to a third
person without the prior permission of Company


PRODUCED BY AN AUTODESK EDUCATIONAL PRODUCT

PRODUCED BY AN AUTODESK EDUCATIONAL PRODUCT



PRODUCED BY AN AUTODESK EDUCATIONAL PRODUCT


The contents of this Drawing are the sole property of C&S ELECTRIC LTD.
and they should neither be copied nor given to a third person without the prior permission of Company

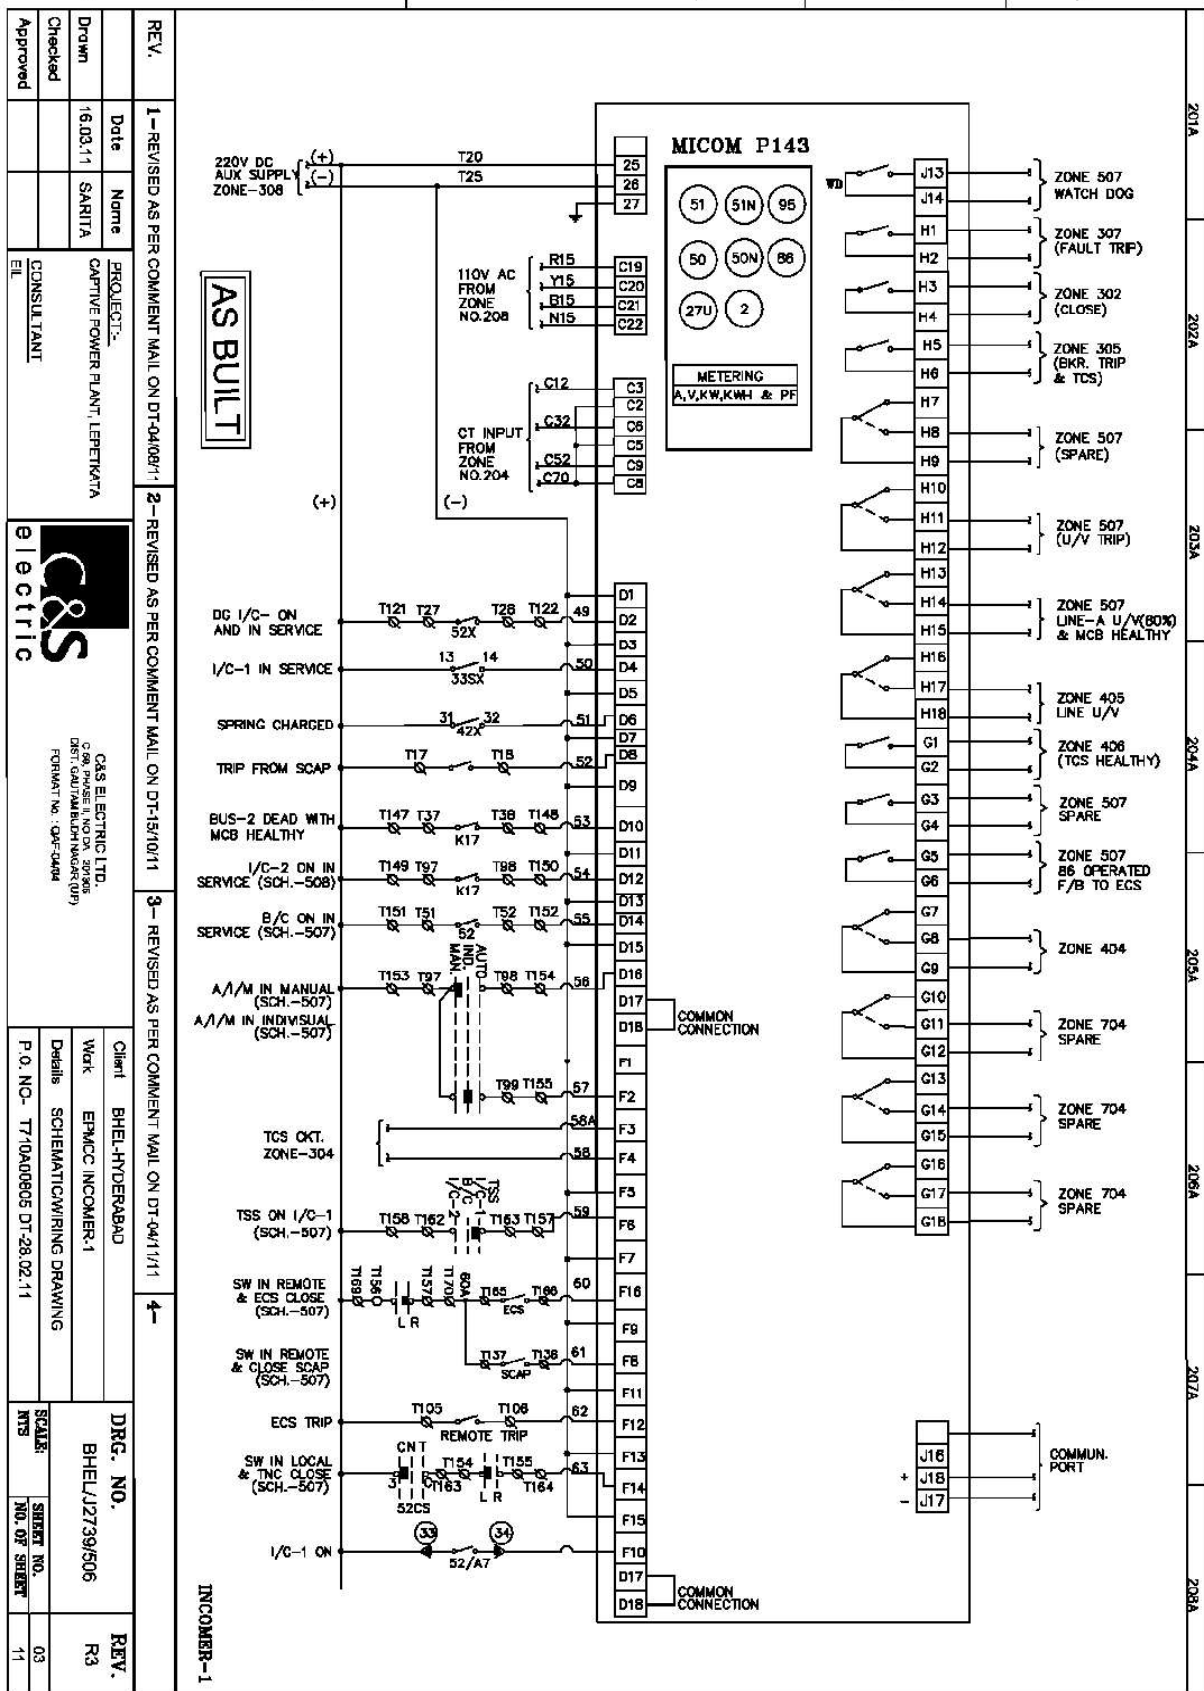

PRODUCED BY AN AUTODESK EDUCATIONAL PRODUCT

PRODUCED BY AN AUTODESK EDUCATIONAL PRODUCT

The contents of this Drawing are the sole property of C&S ELECTRIC LTD.
and they should neither be copied nor given to a third person without the prior permission of Company

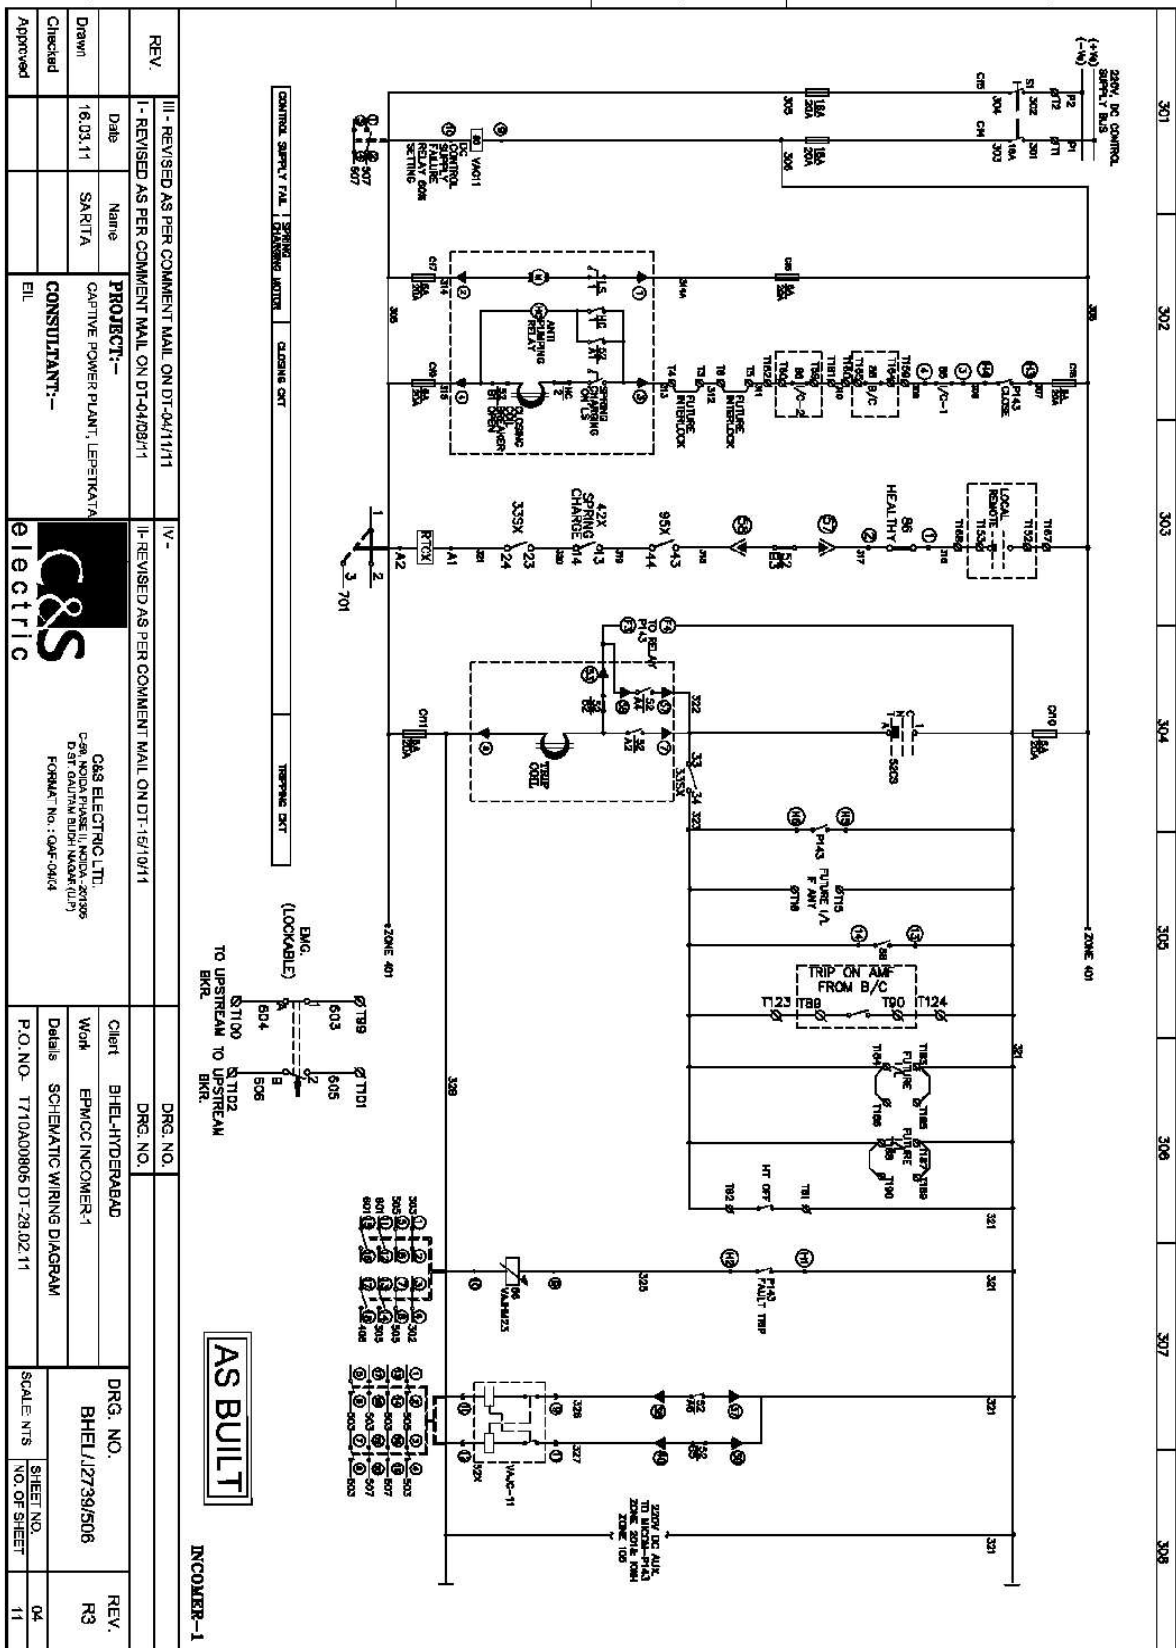


PRODUCED BY AN AUTODESK EDUCATIONAL PRODUCT



PRODUCED BY AN AUTODESK EDUCATIONAL PRODUCT

PRODUCED BY AN AUTODESK EDUCATIONAL PRODUCT

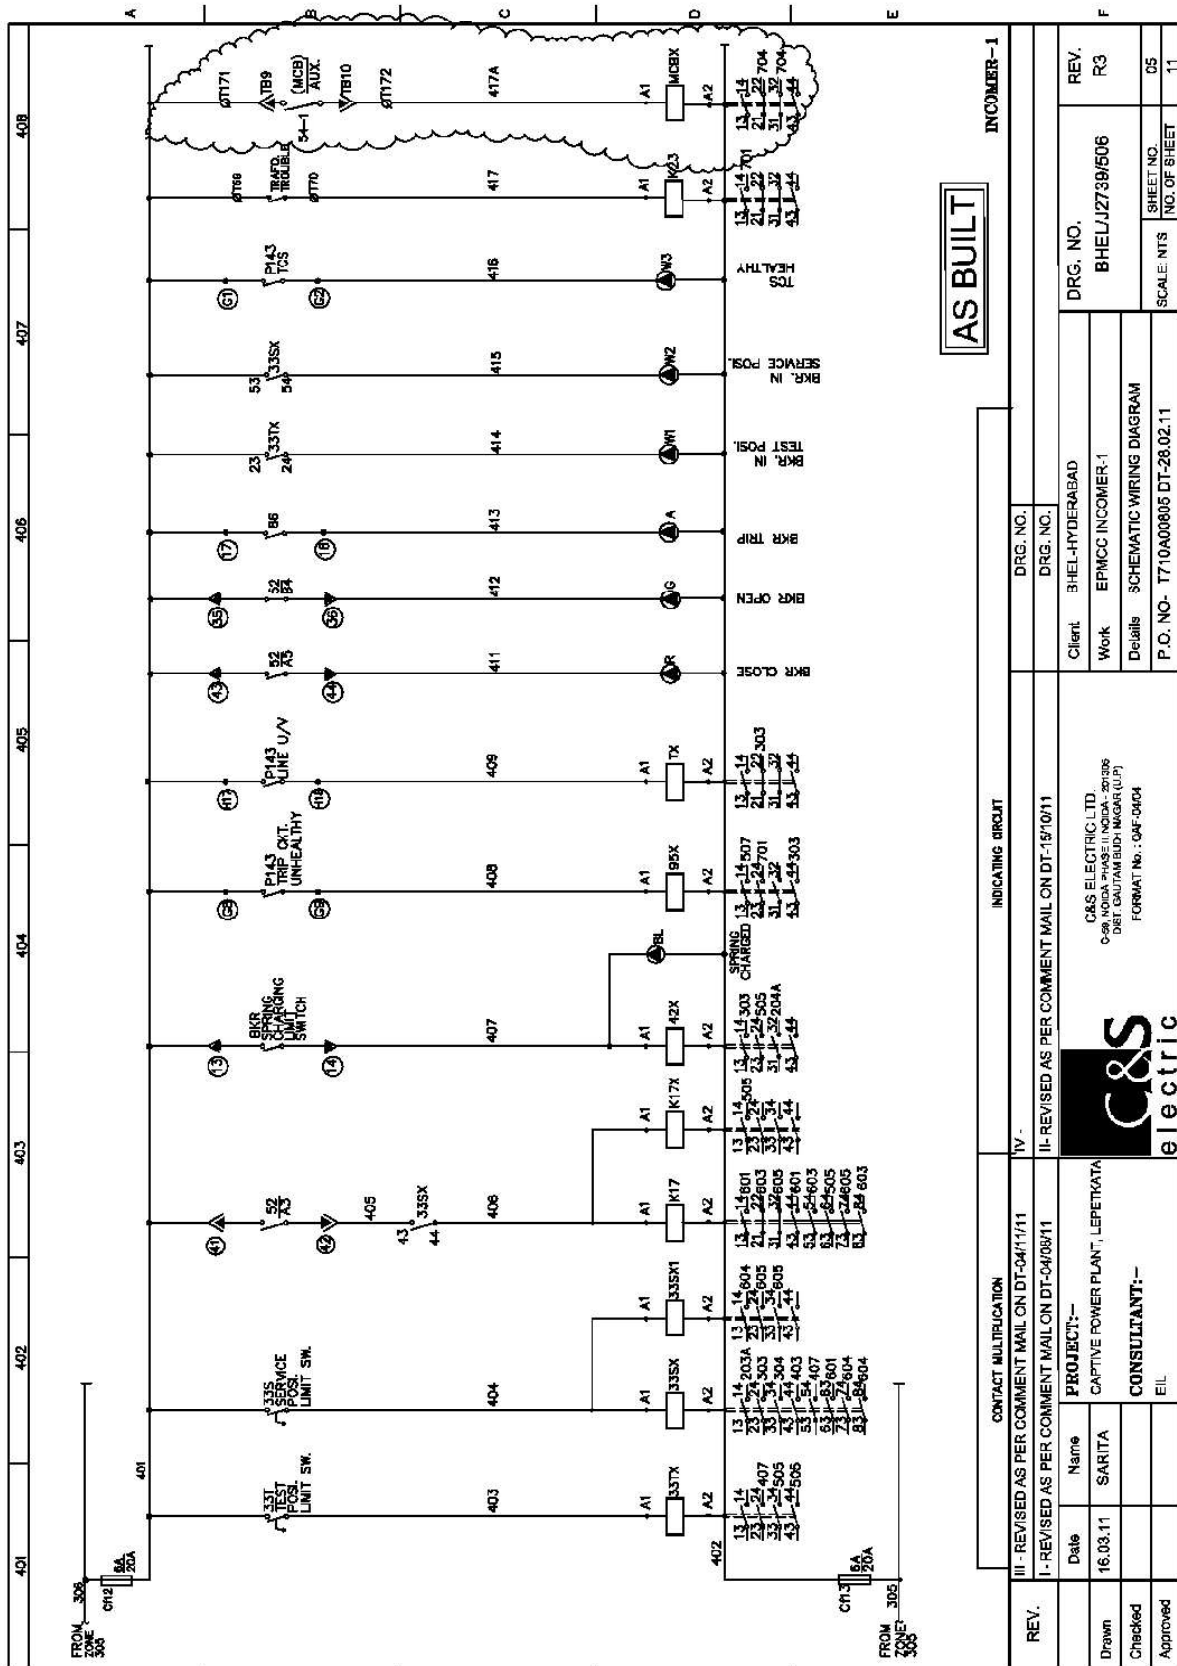

PRODUCED BY AN AUTODESK EDUCATIONAL PRODUCT


The contents of this Drawing are the sole property of C&S ELECTRIC LTD. and they should neither be copied nor given to a third person without the prior permission of Company.

PRODUCED BY AN AUTODESK EDUCATIONAL PRODUCT




PRODUCED BY AN AUTODESK EDUCATIONAL PRODUCT

PRODUCED BY AN AUTODESK EDUCATIONAL PRODUCT

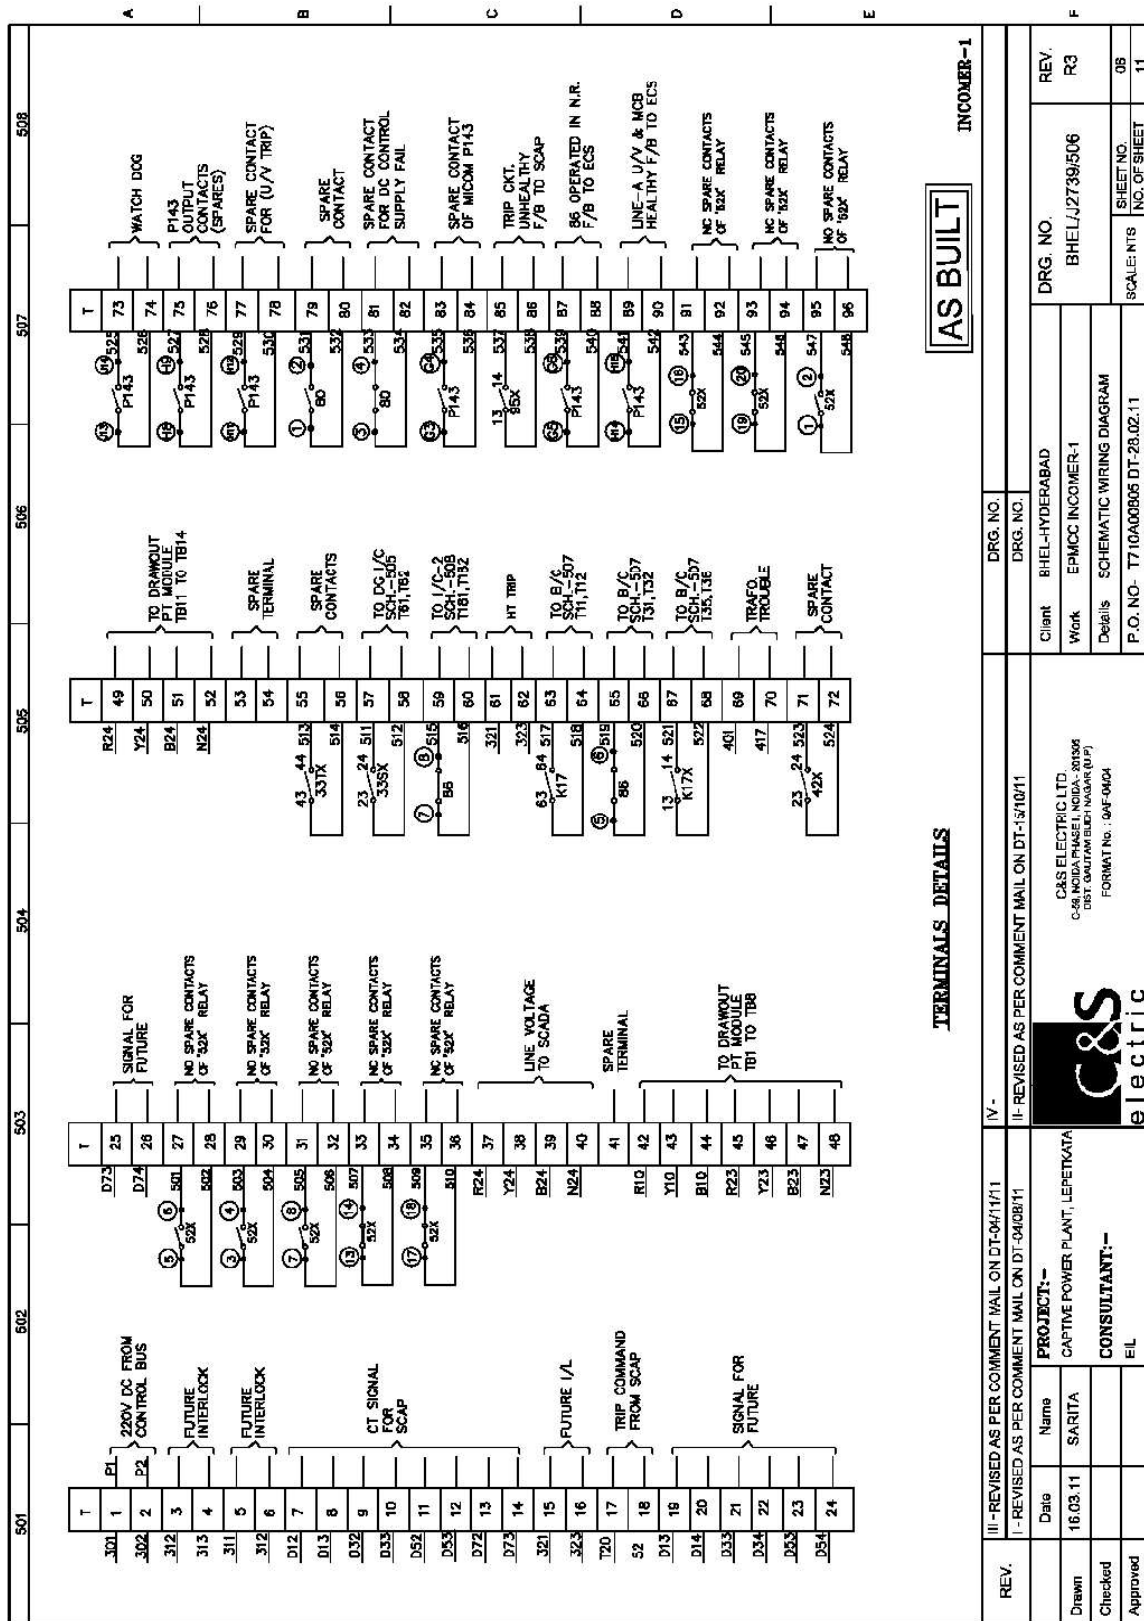


PRODUCED BY AN AUTODESK EDUCATIONAL PRODUCT

 
PRODUCED BY AN AUTODESK EDUCATIONAL PRODUCT




PRODUCED BY AN AUTODESK EDUCATIONAL PRODUCT

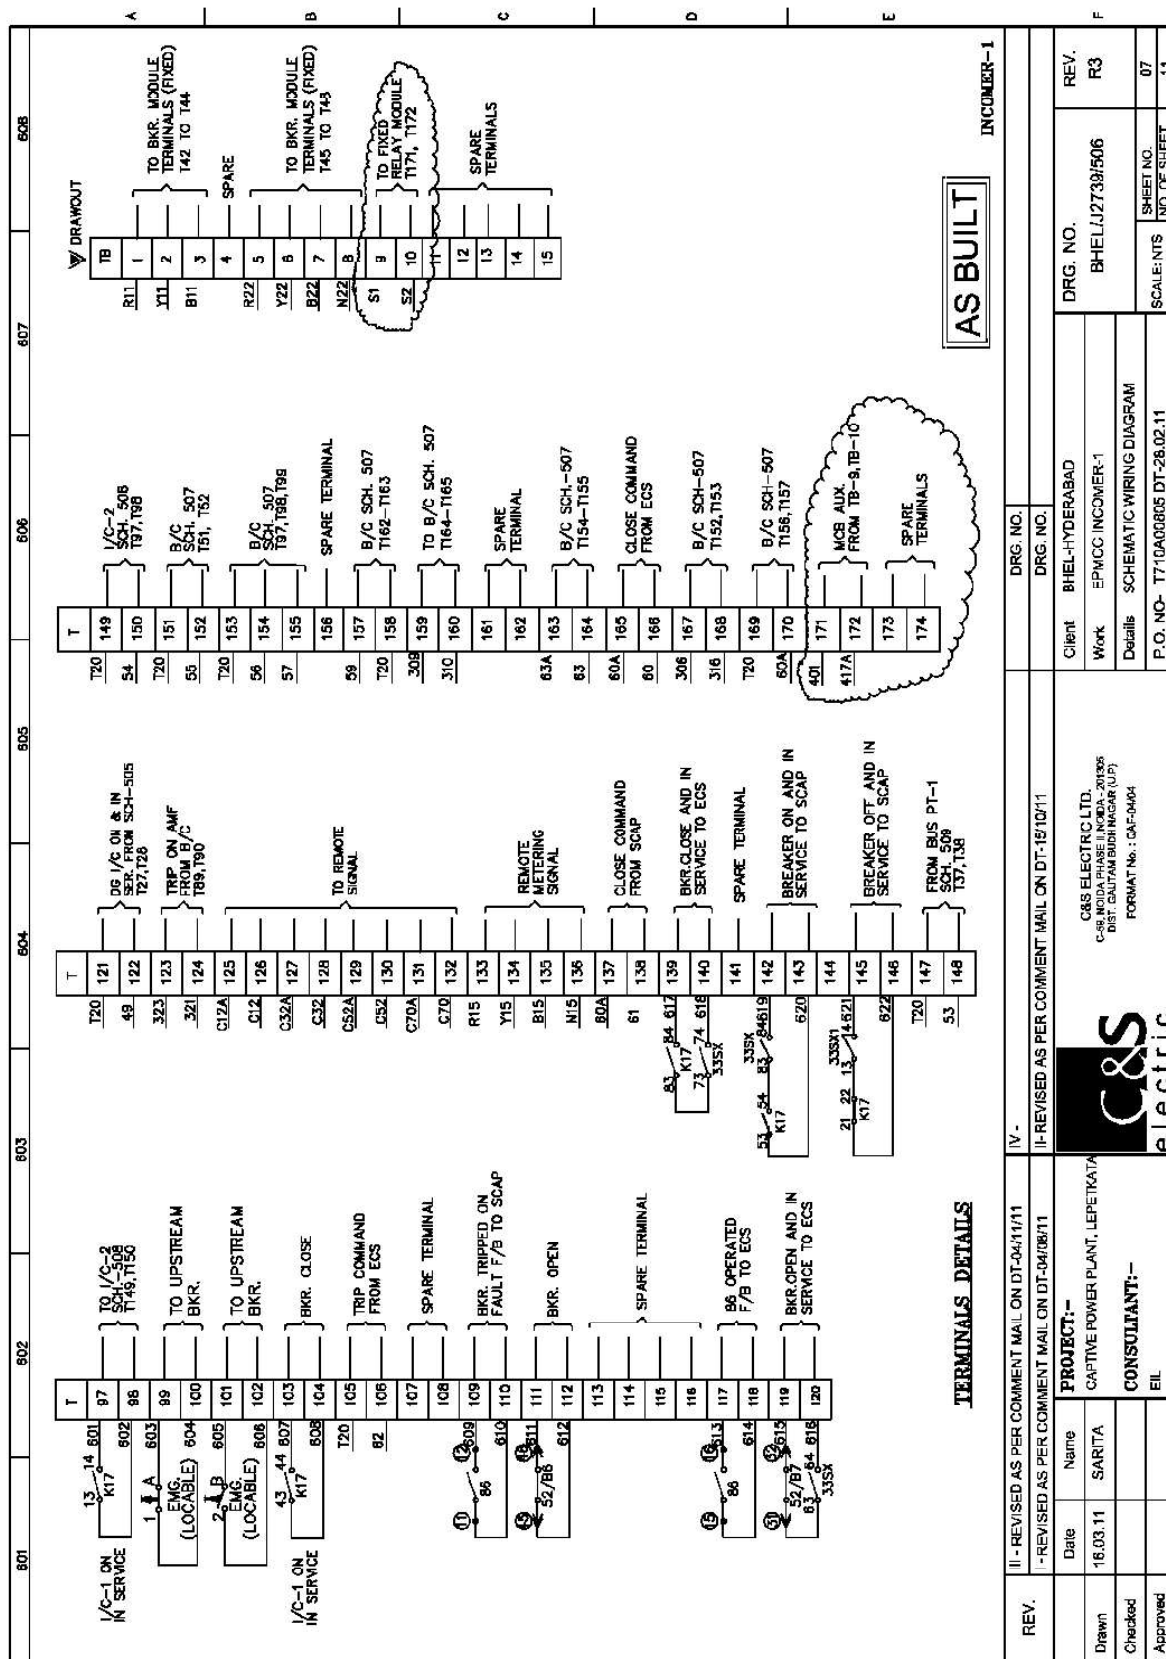

 
PRODUCED BY AN AUTODESK EDUCATIONAL PRODUCT




PRODUCED BY AN AUTODESK EDUCATIONAL PRODUCT

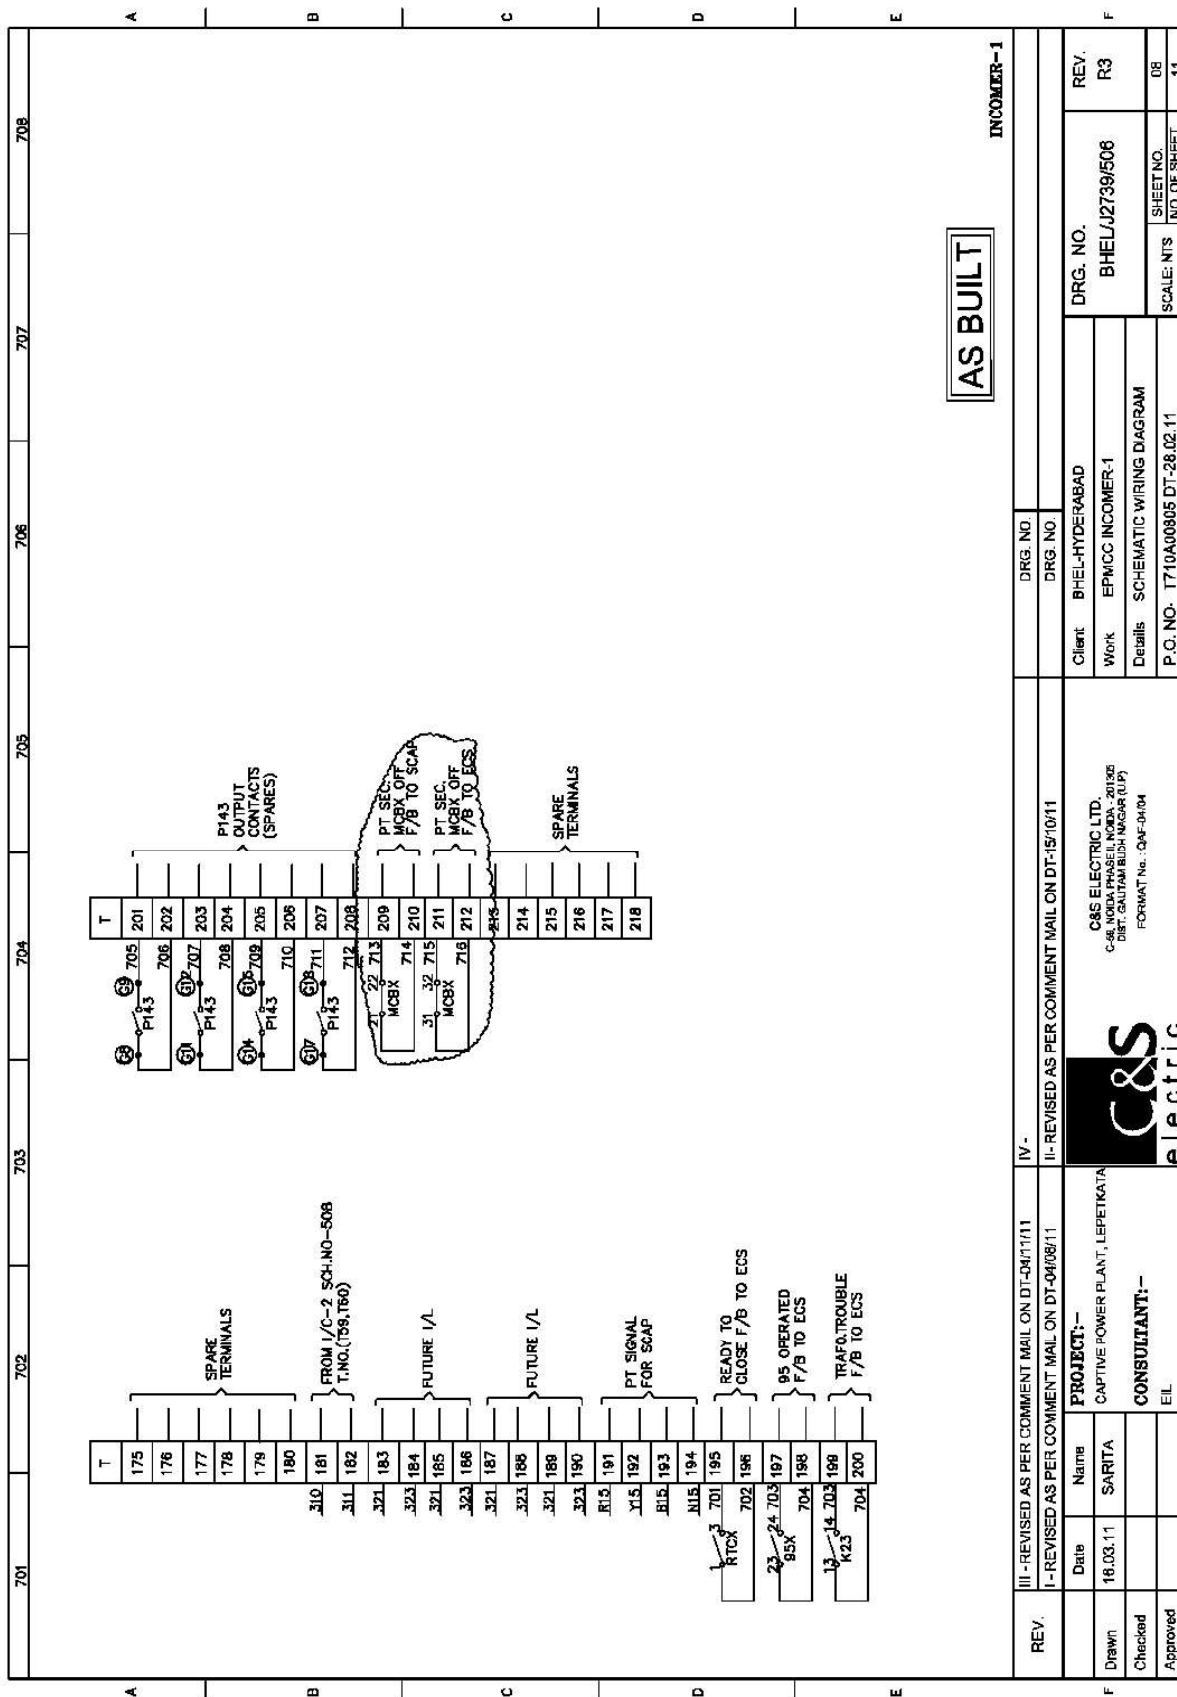

 PRODUCED BY AN AUTODESK EDUCATIONAL PRODUCT



PRODUCED BY AN AUTODESK EDUCATIONAL PRODUCT

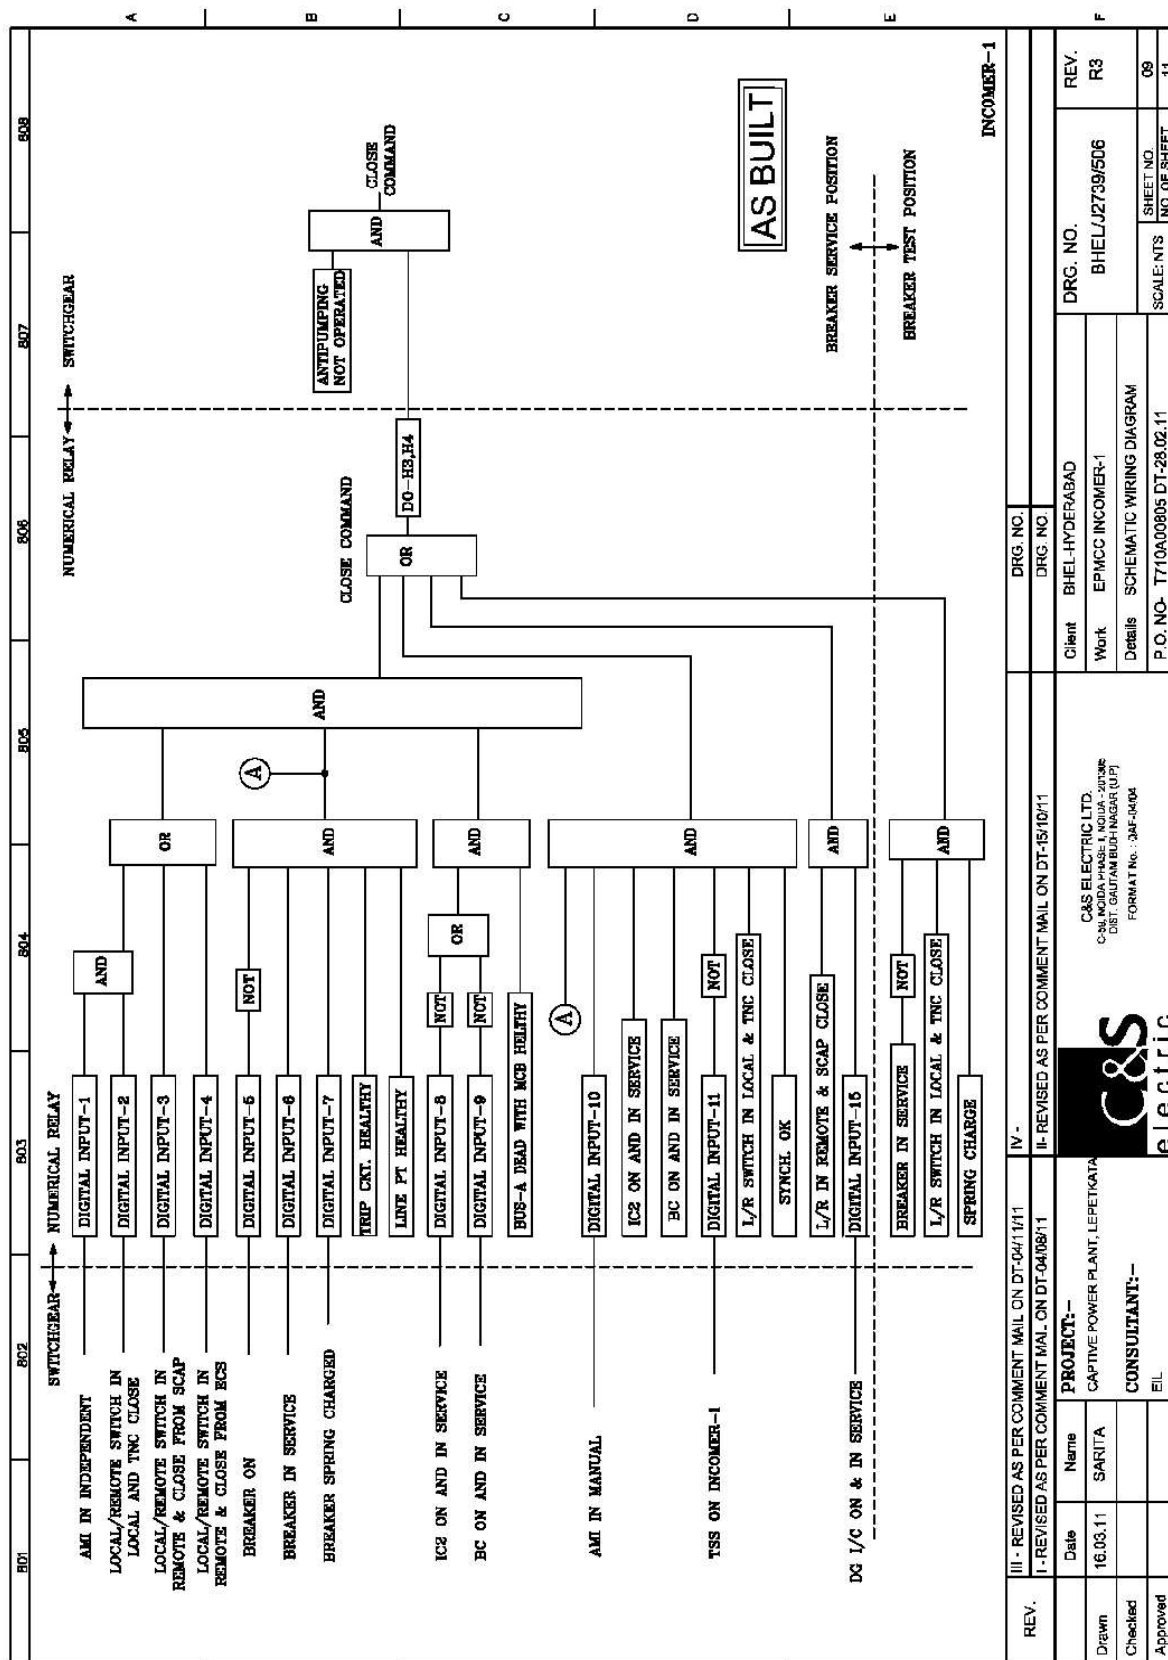


PRODUCED BY AN AUTODESK EDUCATIONAL PRODUCT

PRODUCED BY AN AUTODESK EDUCATIONAL PRODUCT



PRODUCED BY AN AUTODESK EDUCATIONAL PRODUCT

PRODUCED BY AN AUTODESK EDUCATIONAL PRODUCT

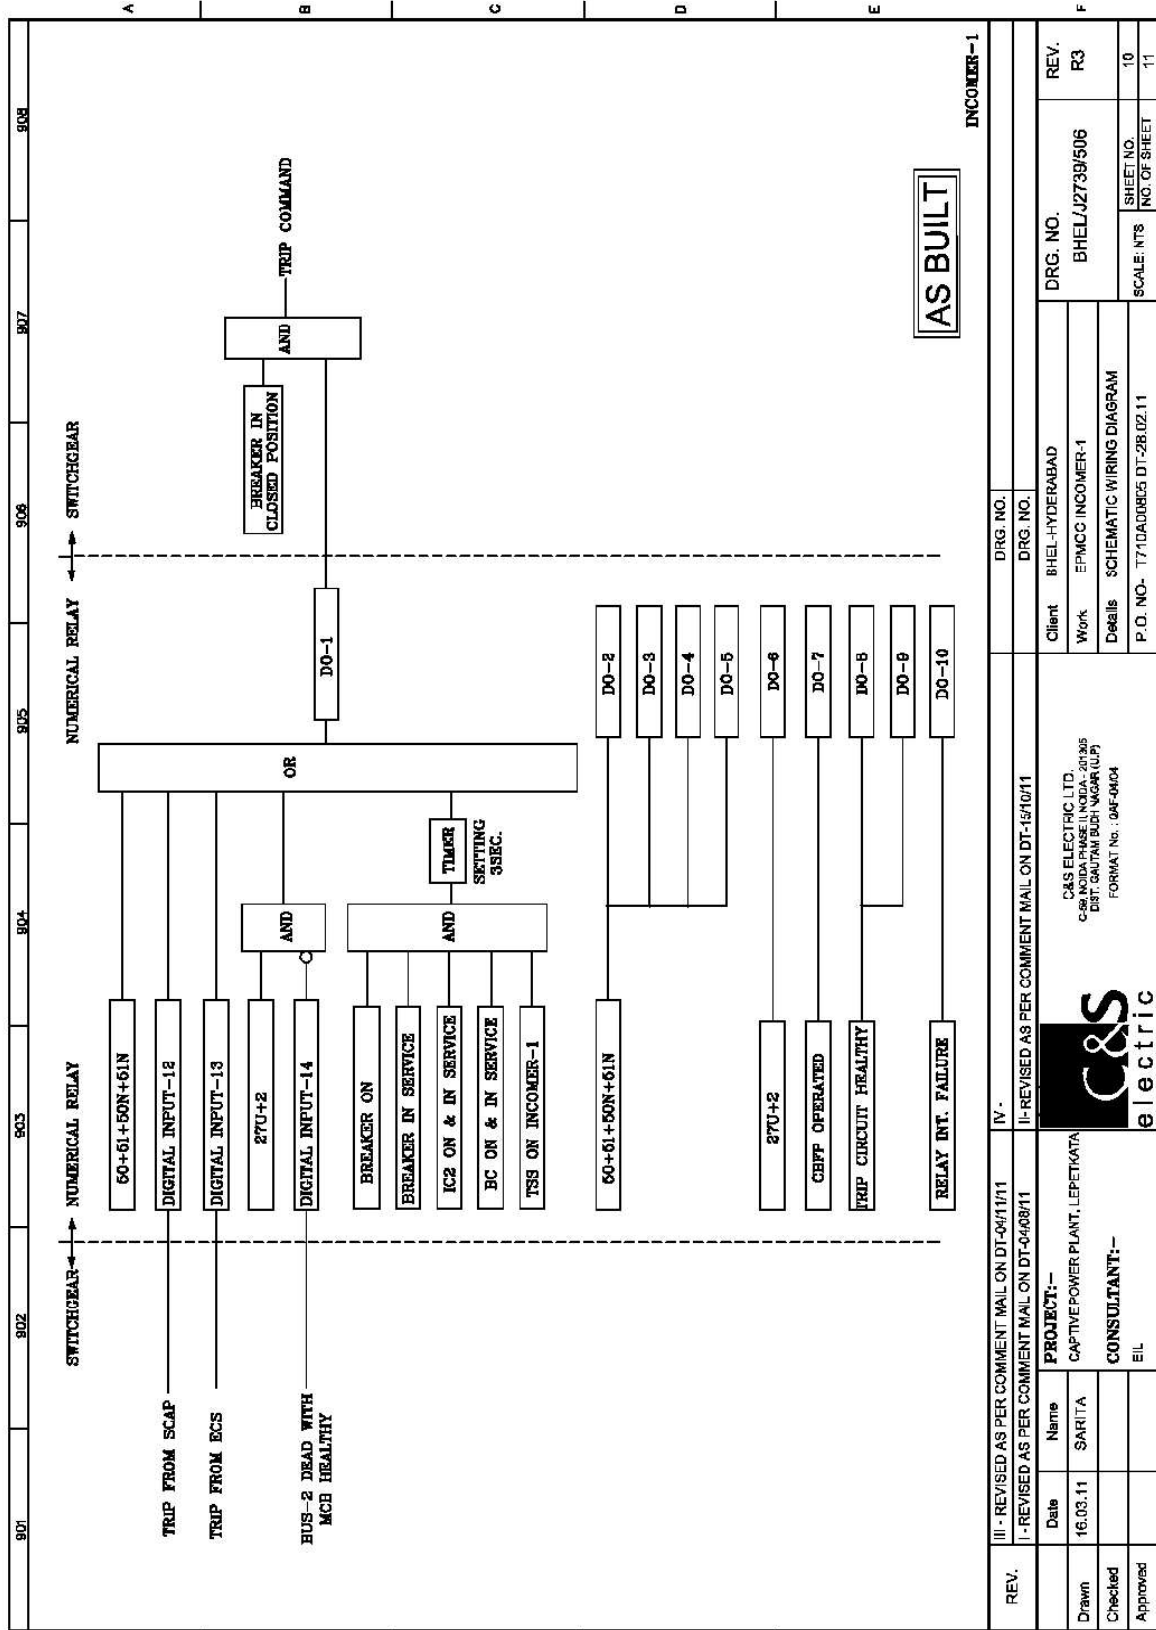

PRODUCED BY AN AUTODESK EDUCATIONAL PRODUCT

PRODUCED BY AN AUTODESK EDUCATIONAL PRODUCT

The contents of this Drawing are the sole property of C&S ELECTRIC LTD. and they should neither be copied nor given to a third person without the prior permission of Company.



PRODUCED BY AN AUTODESK EDUCATIONAL PRODUCT

PRODUCED BY AN AUTODESK EDUCATIONAL PRODUCT

PRODUCED BY AN AUTODESK EDUCATIONAL PRODUCT

REV.	1001	1002	1003	1004	1005	1006	1007	1008																																																																																																																																																																		
PROTECTION FUNCTIONS <table border="1"><thead><tr><th>Sl</th><th>FUNCTION</th></tr></thead><tbody><tr><td>1</td><td>3-PH. DMT/DMT O/C PROTECTION</td></tr><tr><td>2</td><td>3-PH. INST./DMT O/C PROTECTION</td></tr><tr><td>3</td><td>DMT/DMT E/F PROTECTION</td></tr><tr><td>4</td><td>INST./DMT E/F PROTECTION</td></tr><tr><td>5</td><td>LINE UNDER VOLTAGE WITH TIMER</td></tr><tr><td>6</td><td>CHECK SYNCHRONISM</td></tr><tr><td>7</td><td>CIRCUIT BREAKER FAILURE</td></tr></tbody></table> MEASUREMENT FUNCTIONS <table border="1"><thead><tr><th>Sl</th><th>FUNCTION</th></tr></thead><tbody><tr><td>8</td><td>3-PHASE CURRENT MEASUREMENT</td></tr><tr><td>9</td><td>NEUTRAL CURRENT MEASUREMENT</td></tr><tr><td>10</td><td>3-PHASE VOLTAGE MEASUREMENT</td></tr><tr><td>11</td><td>ACTIVE POWER MEASUREMENT</td></tr><tr><td>12</td><td>REACTIVE POWER MEASUREMENT</td></tr><tr><td>13</td><td>ENERGY MEASUREMENT</td></tr><tr><td>14</td><td>POWER FACTOR MEASUREMENT</td></tr></tbody></table> CONDITION MONITORING FEATURES <table border="1"><thead><tr><th>Sl</th><th>FUNCTION</th></tr></thead><tbody><tr><td>15</td><td>RELAY INTERNAL SELF SUPERVISION</td></tr><tr><td>16</td><td>TRIP CIRCUIT SUPERVISION</td></tr><tr><td>17</td><td>BREAKER CONDITION MONITORING</td></tr></tbody></table> OTHER FUNCTIONS AVAILABLE IN RELAY <table border="1"><thead><tr><th>Sl</th><th>FUNCTION</th></tr></thead><tbody><tr><td>18</td><td>CIRCUIT BREAKER CONTROL</td></tr><tr><td>19</td><td>DISTURBANCE RECORDING</td></tr><tr><td>20</td><td>FAULT RECORDING</td></tr><tr><td>21</td><td>EVENT RECORDING</td></tr><tr><td>22</td><td>DOUBLING FEATURE DURING STARTING</td></tr></tbody></table> LED INDICATION ON RELAY <table border="1"><thead><tr><th>LED</th><th>DESCRIPTION</th></tr></thead><tbody><tr><td>1</td><td>DMT OVER CURRENT TRIP</td></tr><tr><td>2</td><td>INST. OVER CURRENT TRIP</td></tr><tr><td>3</td><td>DMT EARTH FAULT TRIP</td></tr><tr><td>4</td><td>INST. EARTH FAULT TRIP</td></tr><tr><td>5</td><td>CIRCUIT BREAKER FAILURE</td></tr><tr><td>6</td><td>TRIP CIRCUIT UNHEALTHY</td></tr><tr><td>7</td><td>DS SPRING NOT CHARGED</td></tr><tr><td>8</td><td>LOCKOUT OPERATED (LO)</td></tr><tr><td>9</td><td>DS CONDITION MONITORING ALARM</td></tr><tr><td>10</td><td>LINE UNDER VOLTAGE</td></tr><tr><td>11</td><td>SYNCHROCHECK OK</td></tr></tbody></table> SIGNALS WIRED TO DI OF RELAY <table border="1"><thead><tr><th>INPUT NO.</th><th>INPUT DES.</th><th>SIGNAL DESCRIPTION</th></tr></thead><tbody><tr><td>D1-1</td><td>D1-F2</td><td>ALI IN INDEPENDENT</td></tr><tr><td>D1-2</td><td>D1-F14</td><td>SW IN LOCAL & TRIP CLOSE</td></tr><tr><td>D1-3</td><td>D1-F8</td><td>SW IN REMOTE & CLOSE FROM SCAP</td></tr><tr><td>D1-4</td><td>D1-F16</td><td>SW IN REMOTE & CLOSE FROM EDS</td></tr><tr><td>D1-5</td><td>D1-F10</td><td>INCOMER-1 ON</td></tr><tr><td>D1-6</td><td>D1-D4</td><td>I/C-1 IN SERVICE</td></tr><tr><td>D1-7</td><td>D1-D8</td><td>SPRING CHARGED</td></tr><tr><td>D1-8</td><td>D1-D12</td><td>MOUSER-2 ON IN SERVICE</td></tr><tr><td>D1-9</td><td>D1-D14</td><td>B/C ON IN SERVICE</td></tr><tr><td>D1-10</td><td>D1-D16</td><td>ALI IN MANUAL</td></tr><tr><td>D1-11</td><td>D1-D18</td><td>TSS ON I/C-1</td></tr><tr><td>D1-12</td><td>D1-D18</td><td>TRIP FROM SCAP</td></tr><tr><td>D1-13</td><td>D1-D12</td><td>TRIP FROM EDS</td></tr><tr><td>D1-14</td><td>D1-D10</td><td>BUS-2 READ WITH MCS HEALTHY</td></tr><tr><td>D1-15</td><td>D1-D12</td><td>DS I/C ON AND IN SERVICE FROM DO I/C</td></tr></tbody></table> OUTPUT CONTACT OF RELAY <table border="1"><thead><tr><th>OUTPUT NO.</th><th>SIGNAL DESCRIPTION</th></tr></thead><tbody><tr><td>H13, H14</td><td>WATCH DOG</td></tr><tr><td>H11, H2</td><td>FAULT TRIP</td></tr><tr><td>H3, H4</td><td>CB CLOSE COMMAND</td></tr><tr><td>H5, H6</td><td>BKR. TRIP & TCS</td></tr><tr><td>H8, H9</td><td>SPARE CONTACT</td></tr><tr><td>H11, H12</td><td>U/Y TRIP</td></tr><tr><td>H14, H15</td><td>LINE-A U/Y</td></tr><tr><td>H17, H18</td><td>LINE U/Y</td></tr><tr><td>G1, G2</td><td>TRIP CIRCUIT HEALTHY</td></tr><tr><td>G3, G4</td><td>SPARE CONTACT</td></tr><tr><td>G6, G8</td><td>DS OPERATED I/FB TO EDS</td></tr><tr><td>G8, G9</td><td>SPARE CONTACT</td></tr><tr><td>G11, G12</td><td>SPARE CONTACT</td></tr><tr><td>G14, G15</td><td>SPARE CONTACT</td></tr><tr><td>G17, G18</td><td>SPARE CONTACT</td></tr></tbody></table> RELAY COMMUNICATION DETAILS <table border="1"><thead><tr><th>FRONT COMMUNICATION PORT</th><th>RS232</th></tr><tr><th>REAR COMMUNICATION PORT</th><th>RS485</th></tr><tr><th>COMMUNICATION PROTOCOL</th><th>IEC-61850</th></tr></thead></table> INCOMER-1 AS BUILT									Sl	FUNCTION	1	3-PH. DMT/DMT O/C PROTECTION	2	3-PH. INST./DMT O/C PROTECTION	3	DMT/DMT E/F PROTECTION	4	INST./DMT E/F PROTECTION	5	LINE UNDER VOLTAGE WITH TIMER	6	CHECK SYNCHRONISM	7	CIRCUIT BREAKER FAILURE	Sl	FUNCTION	8	3-PHASE CURRENT MEASUREMENT	9	NEUTRAL CURRENT MEASUREMENT	10	3-PHASE VOLTAGE MEASUREMENT	11	ACTIVE POWER MEASUREMENT	12	REACTIVE POWER MEASUREMENT	13	ENERGY MEASUREMENT	14	POWER FACTOR MEASUREMENT	Sl	FUNCTION	15	RELAY INTERNAL SELF SUPERVISION	16	TRIP CIRCUIT SUPERVISION	17	BREAKER CONDITION MONITORING	Sl	FUNCTION	18	CIRCUIT BREAKER CONTROL	19	DISTURBANCE RECORDING	20	FAULT RECORDING	21	EVENT RECORDING	22	DOUBLING FEATURE DURING STARTING	LED	DESCRIPTION	1	DMT OVER CURRENT TRIP	2	INST. OVER CURRENT TRIP	3	DMT EARTH FAULT TRIP	4	INST. EARTH FAULT TRIP	5	CIRCUIT BREAKER FAILURE	6	TRIP CIRCUIT UNHEALTHY	7	DS SPRING NOT CHARGED	8	LOCKOUT OPERATED (LO)	9	DS CONDITION MONITORING ALARM	10	LINE UNDER VOLTAGE	11	SYNCHROCHECK OK	INPUT NO.	INPUT DES.	SIGNAL DESCRIPTION	D1-1	D1-F2	ALI IN INDEPENDENT	D1-2	D1-F14	SW IN LOCAL & TRIP CLOSE	D1-3	D1-F8	SW IN REMOTE & CLOSE FROM SCAP	D1-4	D1-F16	SW IN REMOTE & CLOSE FROM EDS	D1-5	D1-F10	INCOMER-1 ON	D1-6	D1-D4	I/C-1 IN SERVICE	D1-7	D1-D8	SPRING CHARGED	D1-8	D1-D12	MOUSER-2 ON IN SERVICE	D1-9	D1-D14	B/C ON IN SERVICE	D1-10	D1-D16	ALI IN MANUAL	D1-11	D1-D18	TSS ON I/C-1	D1-12	D1-D18	TRIP FROM SCAP	D1-13	D1-D12	TRIP FROM EDS	D1-14	D1-D10	BUS-2 READ WITH MCS HEALTHY	D1-15	D1-D12	DS I/C ON AND IN SERVICE FROM DO I/C	OUTPUT NO.	SIGNAL DESCRIPTION	H13, H14	WATCH DOG	H11, H2	FAULT TRIP	H3, H4	CB CLOSE COMMAND	H5, H6	BKR. TRIP & TCS	H8, H9	SPARE CONTACT	H11, H12	U/Y TRIP	H14, H15	LINE-A U/Y	H17, H18	LINE U/Y	G1, G2	TRIP CIRCUIT HEALTHY	G3, G4	SPARE CONTACT	G6, G8	DS OPERATED I/FB TO EDS	G8, G9	SPARE CONTACT	G11, G12	SPARE CONTACT	G14, G15	SPARE CONTACT	G17, G18	SPARE CONTACT	FRONT COMMUNICATION PORT	RS232	REAR COMMUNICATION PORT	RS485	COMMUNICATION PROTOCOL	IEC-61850
Sl	FUNCTION																																																																																																																																																																									
1	3-PH. DMT/DMT O/C PROTECTION																																																																																																																																																																									
2	3-PH. INST./DMT O/C PROTECTION																																																																																																																																																																									
3	DMT/DMT E/F PROTECTION																																																																																																																																																																									
4	INST./DMT E/F PROTECTION																																																																																																																																																																									
5	LINE UNDER VOLTAGE WITH TIMER																																																																																																																																																																									
6	CHECK SYNCHRONISM																																																																																																																																																																									
7	CIRCUIT BREAKER FAILURE																																																																																																																																																																									
Sl	FUNCTION																																																																																																																																																																									
8	3-PHASE CURRENT MEASUREMENT																																																																																																																																																																									
9	NEUTRAL CURRENT MEASUREMENT																																																																																																																																																																									
10	3-PHASE VOLTAGE MEASUREMENT																																																																																																																																																																									
11	ACTIVE POWER MEASUREMENT																																																																																																																																																																									
12	REACTIVE POWER MEASUREMENT																																																																																																																																																																									
13	ENERGY MEASUREMENT																																																																																																																																																																									
14	POWER FACTOR MEASUREMENT																																																																																																																																																																									
Sl	FUNCTION																																																																																																																																																																									
15	RELAY INTERNAL SELF SUPERVISION																																																																																																																																																																									
16	TRIP CIRCUIT SUPERVISION																																																																																																																																																																									
17	BREAKER CONDITION MONITORING																																																																																																																																																																									
Sl	FUNCTION																																																																																																																																																																									
18	CIRCUIT BREAKER CONTROL																																																																																																																																																																									
19	DISTURBANCE RECORDING																																																																																																																																																																									
20	FAULT RECORDING																																																																																																																																																																									
21	EVENT RECORDING																																																																																																																																																																									
22	DOUBLING FEATURE DURING STARTING																																																																																																																																																																									
LED	DESCRIPTION																																																																																																																																																																									
1	DMT OVER CURRENT TRIP																																																																																																																																																																									
2	INST. OVER CURRENT TRIP																																																																																																																																																																									
3	DMT EARTH FAULT TRIP																																																																																																																																																																									
4	INST. EARTH FAULT TRIP																																																																																																																																																																									
5	CIRCUIT BREAKER FAILURE																																																																																																																																																																									
6	TRIP CIRCUIT UNHEALTHY																																																																																																																																																																									
7	DS SPRING NOT CHARGED																																																																																																																																																																									
8	LOCKOUT OPERATED (LO)																																																																																																																																																																									
9	DS CONDITION MONITORING ALARM																																																																																																																																																																									
10	LINE UNDER VOLTAGE																																																																																																																																																																									
11	SYNCHROCHECK OK																																																																																																																																																																									
INPUT NO.	INPUT DES.	SIGNAL DESCRIPTION																																																																																																																																																																								
D1-1	D1-F2	ALI IN INDEPENDENT																																																																																																																																																																								
D1-2	D1-F14	SW IN LOCAL & TRIP CLOSE																																																																																																																																																																								
D1-3	D1-F8	SW IN REMOTE & CLOSE FROM SCAP																																																																																																																																																																								
D1-4	D1-F16	SW IN REMOTE & CLOSE FROM EDS																																																																																																																																																																								
D1-5	D1-F10	INCOMER-1 ON																																																																																																																																																																								
D1-6	D1-D4	I/C-1 IN SERVICE																																																																																																																																																																								
D1-7	D1-D8	SPRING CHARGED																																																																																																																																																																								
D1-8	D1-D12	MOUSER-2 ON IN SERVICE																																																																																																																																																																								
D1-9	D1-D14	B/C ON IN SERVICE																																																																																																																																																																								
D1-10	D1-D16	ALI IN MANUAL																																																																																																																																																																								
D1-11	D1-D18	TSS ON I/C-1																																																																																																																																																																								
D1-12	D1-D18	TRIP FROM SCAP																																																																																																																																																																								
D1-13	D1-D12	TRIP FROM EDS																																																																																																																																																																								
D1-14	D1-D10	BUS-2 READ WITH MCS HEALTHY																																																																																																																																																																								
D1-15	D1-D12	DS I/C ON AND IN SERVICE FROM DO I/C																																																																																																																																																																								
OUTPUT NO.	SIGNAL DESCRIPTION																																																																																																																																																																									
H13, H14	WATCH DOG																																																																																																																																																																									
H11, H2	FAULT TRIP																																																																																																																																																																									
H3, H4	CB CLOSE COMMAND																																																																																																																																																																									
H5, H6	BKR. TRIP & TCS																																																																																																																																																																									
H8, H9	SPARE CONTACT																																																																																																																																																																									
H11, H12	U/Y TRIP																																																																																																																																																																									
H14, H15	LINE-A U/Y																																																																																																																																																																									
H17, H18	LINE U/Y																																																																																																																																																																									
G1, G2	TRIP CIRCUIT HEALTHY																																																																																																																																																																									
G3, G4	SPARE CONTACT																																																																																																																																																																									
G6, G8	DS OPERATED I/FB TO EDS																																																																																																																																																																									
G8, G9	SPARE CONTACT																																																																																																																																																																									
G11, G12	SPARE CONTACT																																																																																																																																																																									
G14, G15	SPARE CONTACT																																																																																																																																																																									
G17, G18	SPARE CONTACT																																																																																																																																																																									
FRONT COMMUNICATION PORT	RS232																																																																																																																																																																									
REAR COMMUNICATION PORT	RS485																																																																																																																																																																									
COMMUNICATION PROTOCOL	IEC-61850																																																																																																																																																																									
REV.	III - REVISED AS PER COMMENT MAIL ON DT-04/11/11 I - REVISED AS PER COMMENT MAIL ON DT-04/08/11	IV - II - REVISED AS PER COMMENT MAIL ON DT-15/10/11																																																																																																																																																																								
Drawn	Date	Name	PROJECT:- CAPTIVE POWER PLANT, LEPTAKATA	C&S electric																																																																																																																																																																						
Checked	16.03.11	SARITA		C&S ELECTRIC LTD. C-5, SECTOR-10, INDUSTRIAL AREA, LEPTAKATA DIST. CHITRAKOOT, PIN-741004 (U.P.) FORMAT NO.: QAF-0404																																																																																																																																																																						
Approved			CONSULTANT:- EIL	Client: BHEL-HYDERABAD Work: EPMCC INCOMER-1 Details: SCHEMATIC WIRING DIAGRAM P.O. NO.: T7710A00805 DT-28.02.11																																																																																																																																																																						
				DRG. NO. BHEL/J2739/506 REV. R3																																																																																																																																																																						
				SHEET NO. 11 NO. OF SHEET 11																																																																																																																																																																						
				SCALE NTS																																																																																																																																																																						


PRODUCED BY AN AUTODESK EDUCATIONAL PRODUCT

The contents of this Drawing are the sole property of C&S ELECTRIC LTD. and they should neither be copied nor given to a third person without the prior permission of Company.



PRODUCED BY AN AUTODESK EDUCATIONAL PRODUCT

PRODUCED BY AN AUTODESK EDUCATIONAL PRODUCT

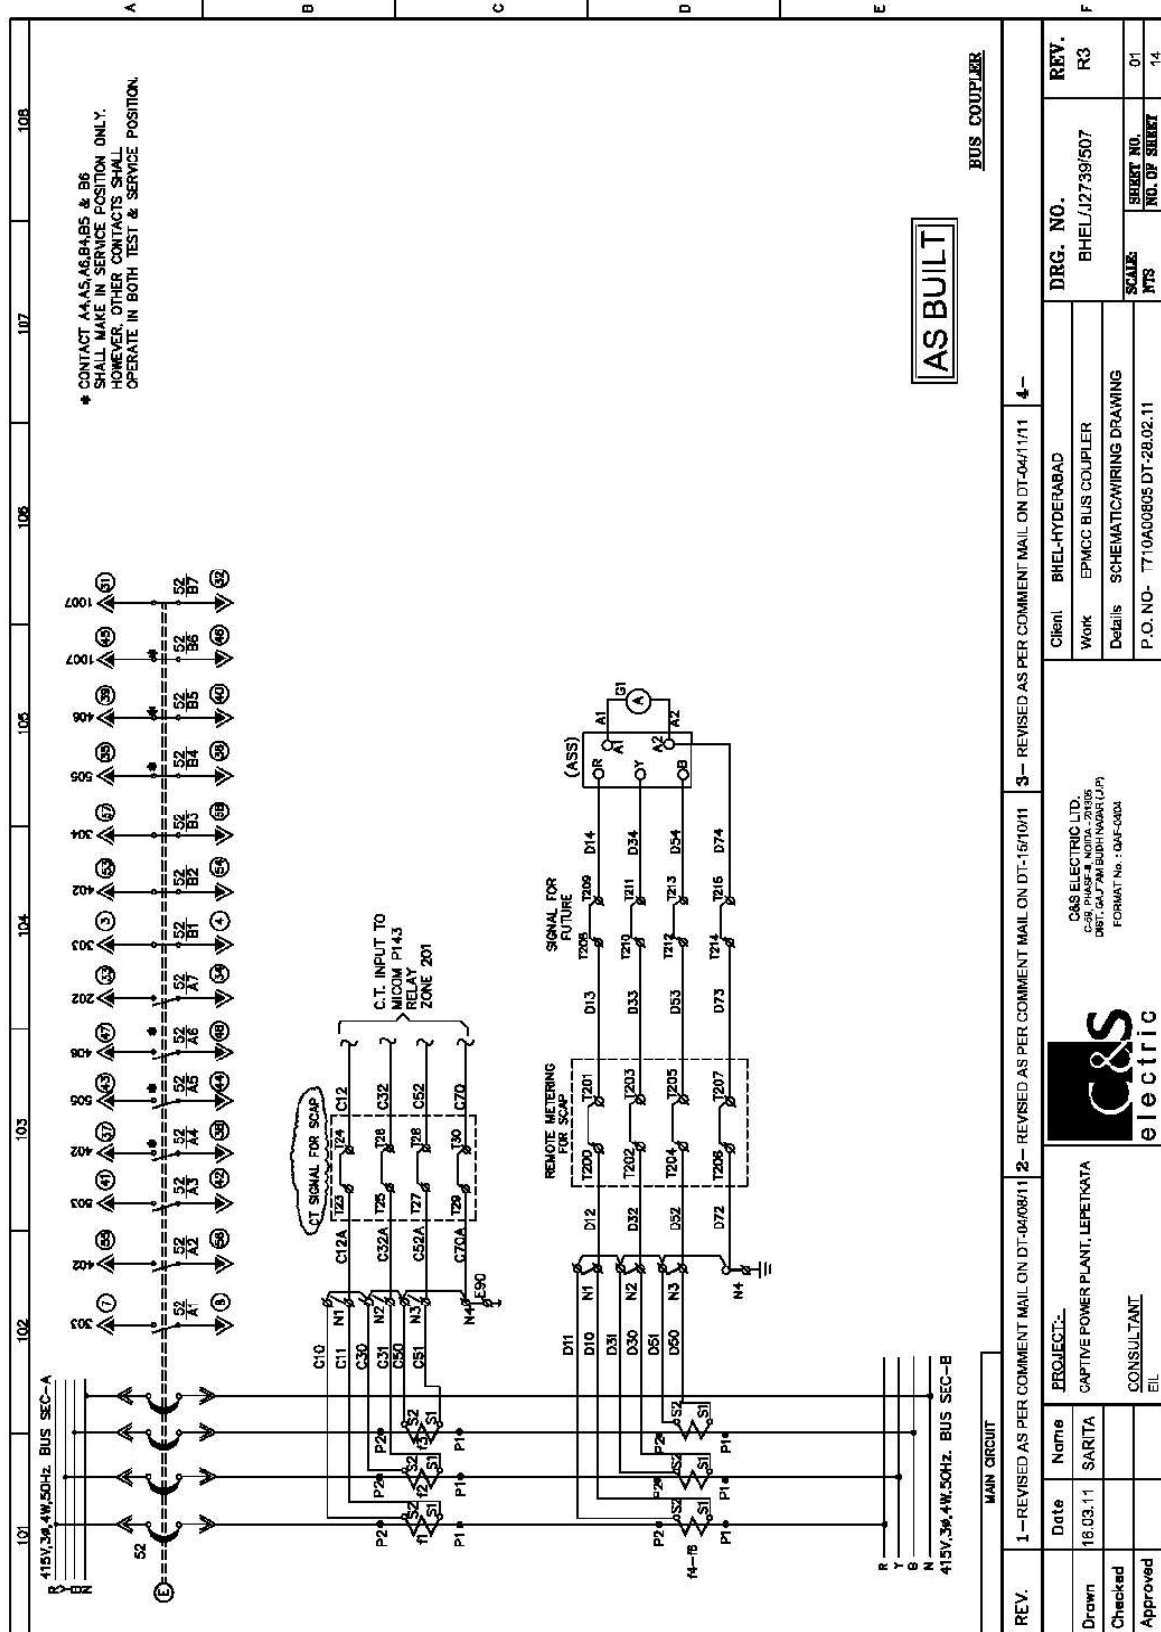

The contents of this Drawing are the sole property of C&S ELECTRIC LTD. and they should neither be copied nor given to a third person without the prior permission of Company.


PRODUCED BY AN AUTODESK EDUCATIONAL PRODUCT

PRODUCED BY AN AUTODESK EDUCATIONAL PRODUCT




PRODUCED BY AN AUTODESK EDUCATIONAL PRODUCT

The contents of this Drawing are the sole property of C&S ELECTRIC LTD.
and they should neither be copied nor given to a third person without the prior permission of Company

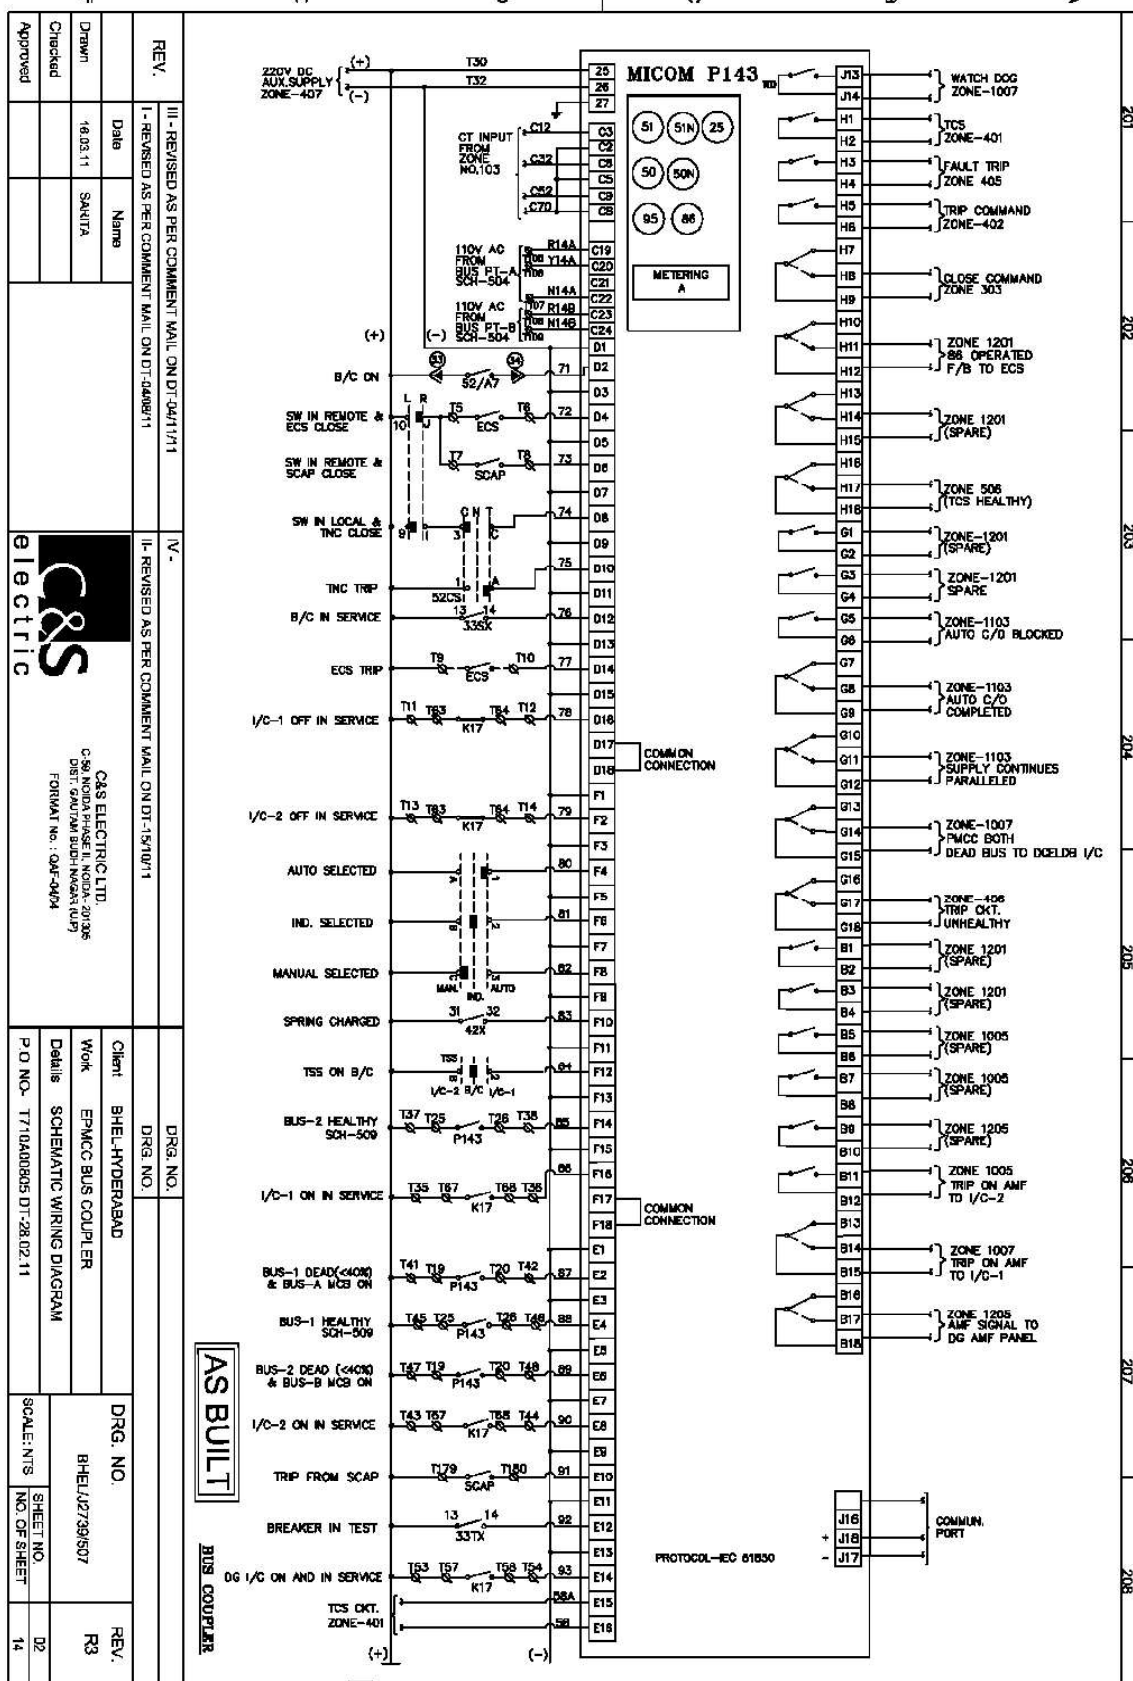


PRODUCED BY AN AUTODESK EDUCATIONAL PRODUCT

 PRODUCED BY AN AUTODESK EDUCATIONAL PRODUCT




PRODUCED BY AN AUTODESK EDUCATIONAL PRODUCT

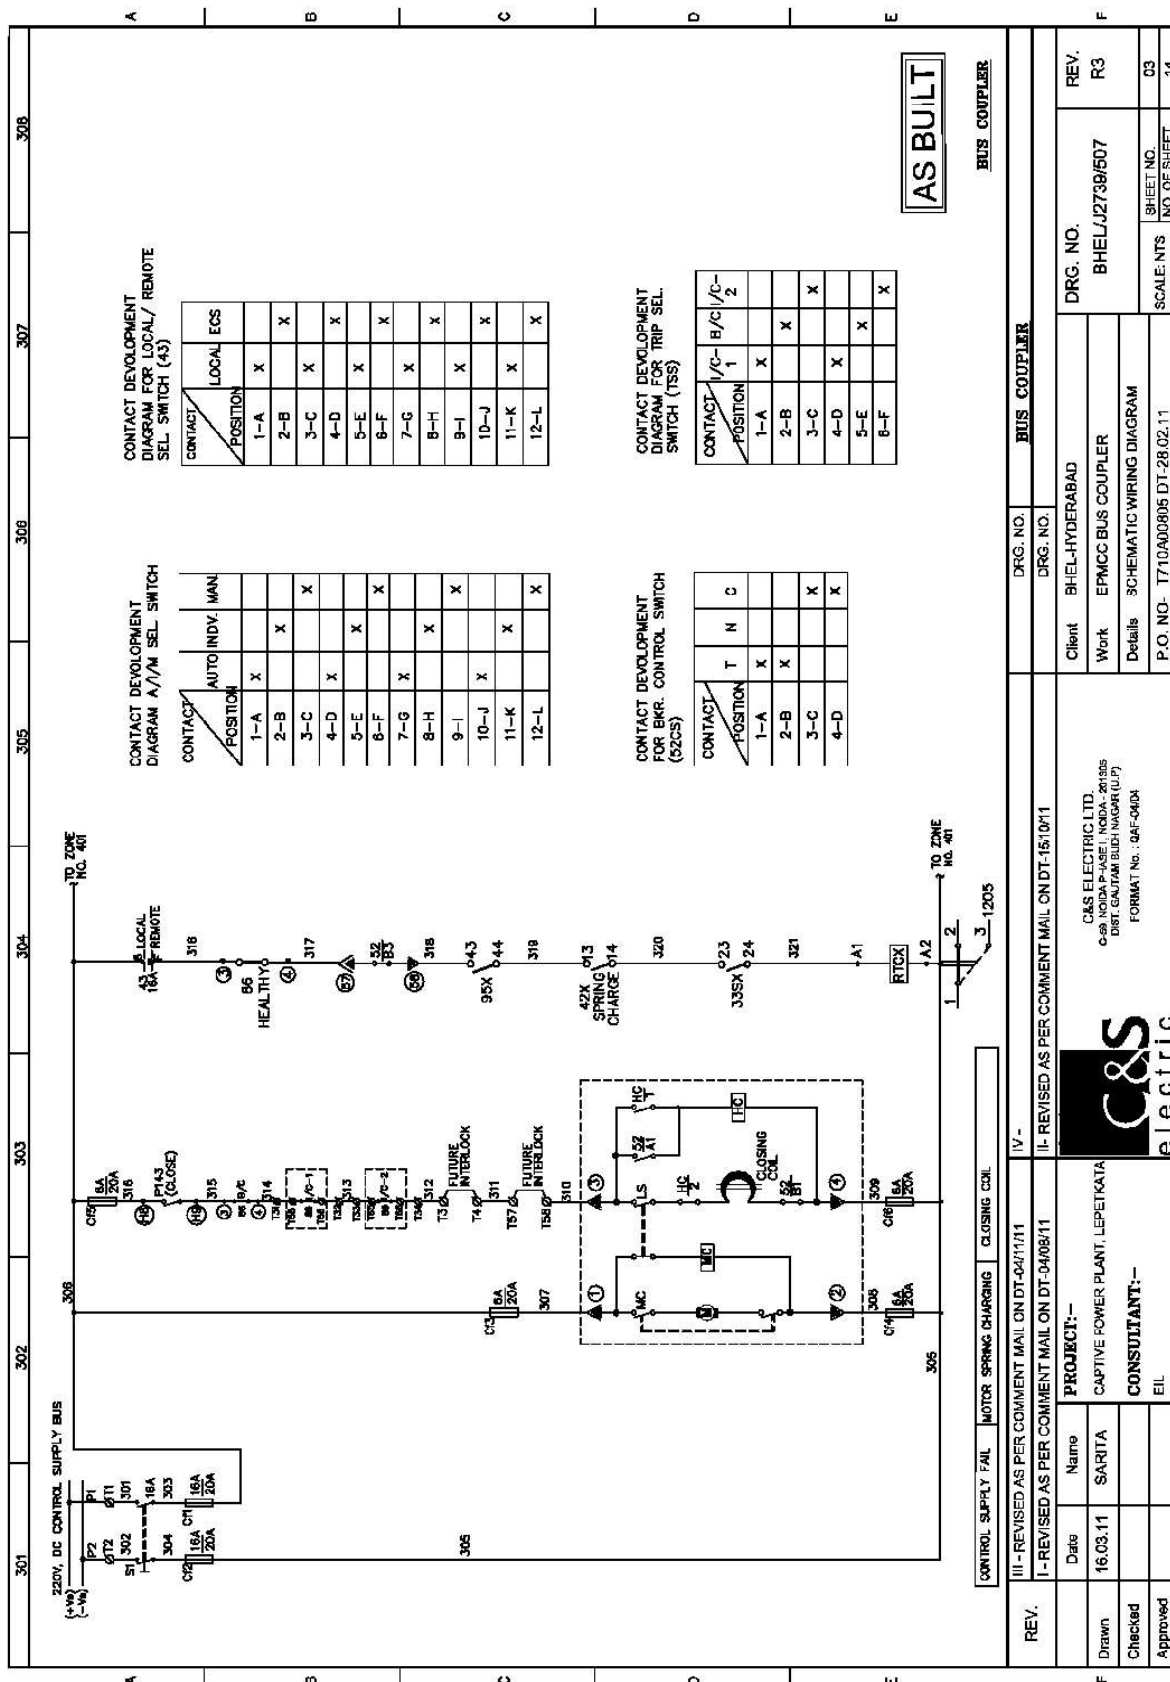


PRODUCED BY AN AUTODESK EDUCATIONAL PRODUCT

 PRODUCED BY AN AUTODESK EDUCATIONAL PRODUCT



PRODUCED BY AN AUTODESK EDUCATIONAL PRODUCT

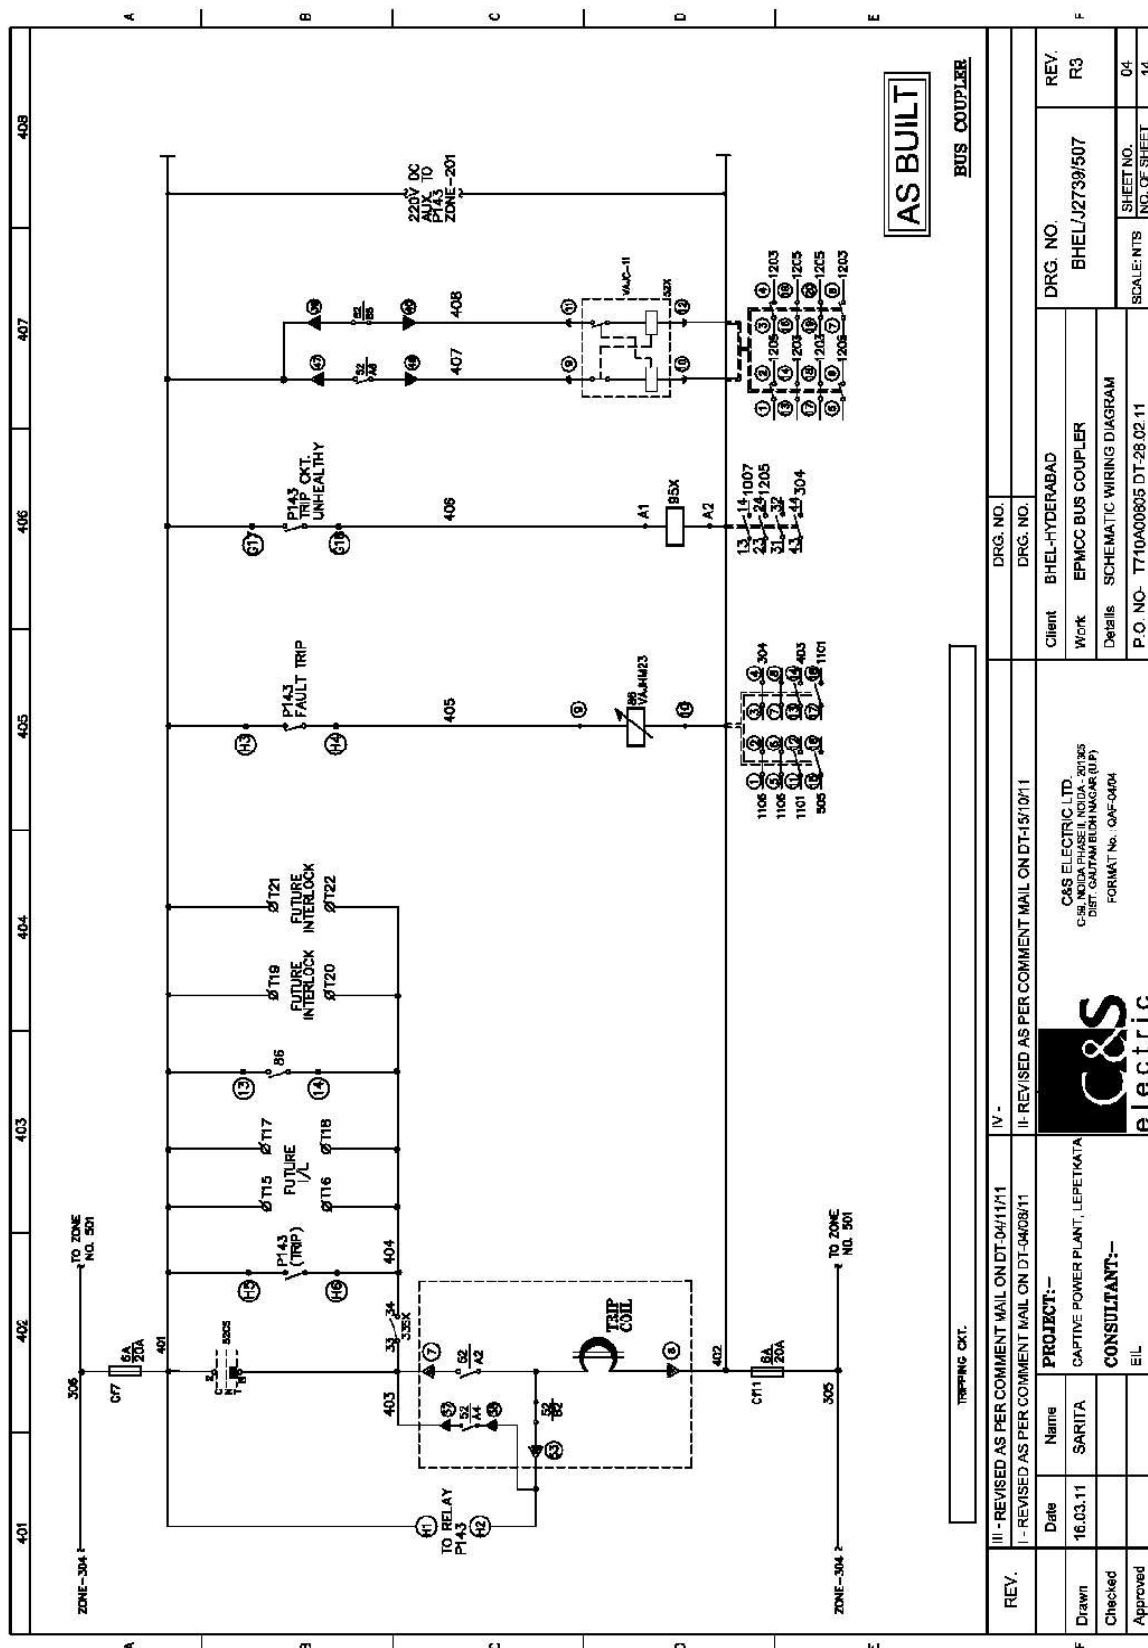

The contents of this Drawing are the sole property of CAS ELECTRIC LTD. and they should neither be copied nor given to a third person without the prior permission of Company


PRODUCED BY AN AUTODESK EDUCATIONAL PRODUCT

PRODUCED BY AN AUTODESK EDUCATIONAL PRODUCT



PRODUCED BY AN AUTODESK EDUCATIONAL PRODUCT


PRODUCED BY AN AUTODESK EDUCATIONAL PRODUCT

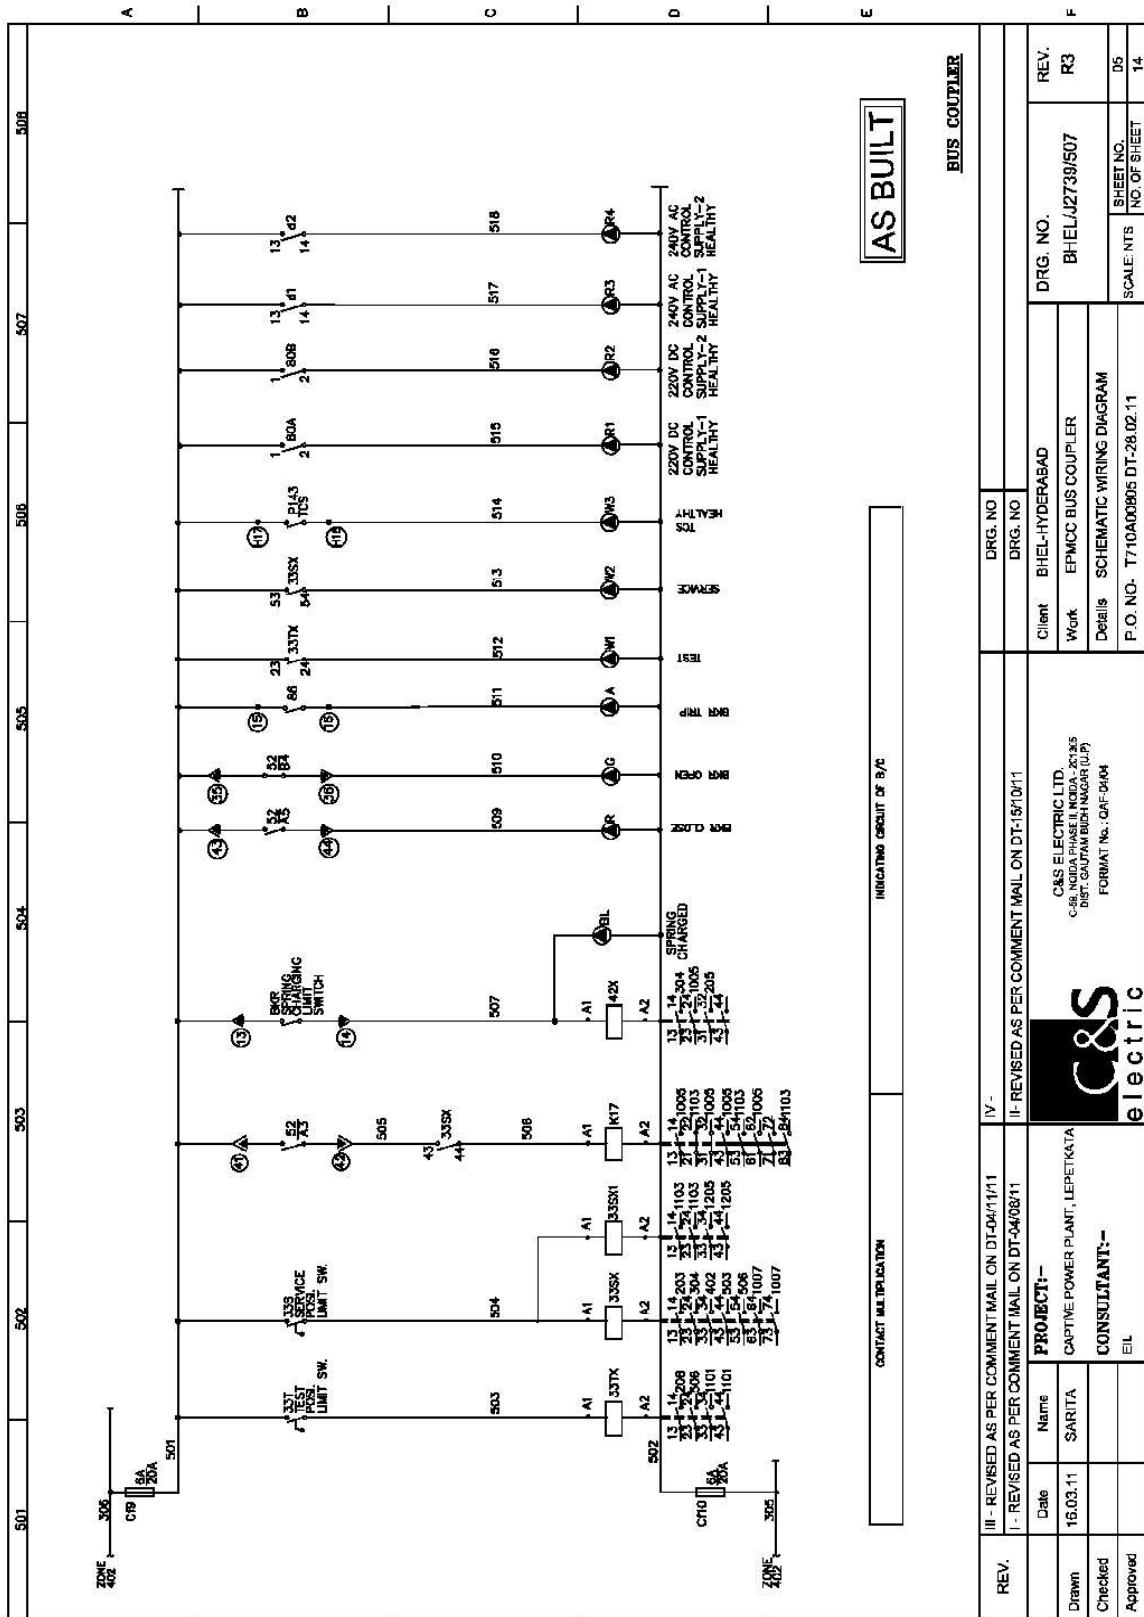


The contents of this Drawing are the sole property of C&S ELECTRIC LTD. and they should neither be copied nor given to a third person without the prior permission of Company

PRODUCED BY AN AUTODESK EDUCATIONAL PRODUCT

 PRODUCED BY AN AUTODESK EDUCATIONAL PRODUCT



PRODUCED BY AN AUTODESK EDUCATIONAL PRODUCT

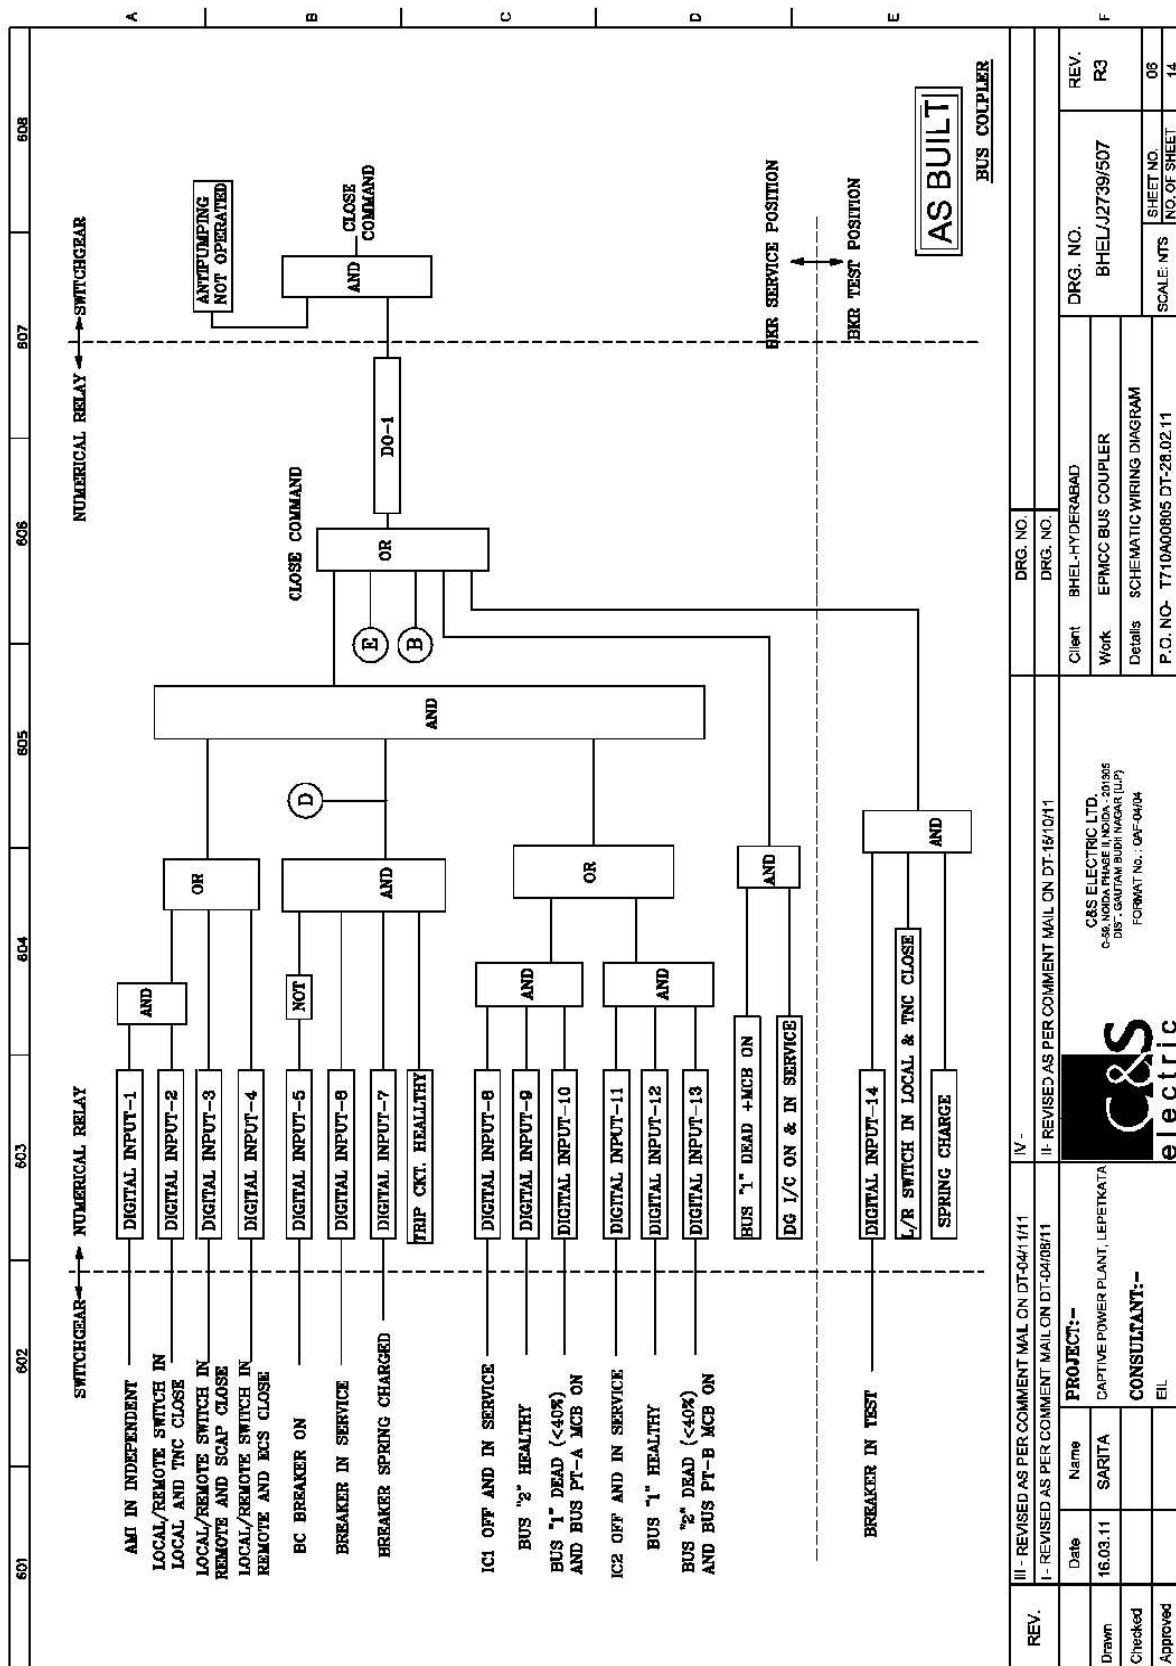


PRODUCED BY AN ADOBE SYSTEMS INC. PRODUCT

PRODUCED BY AN AUTODESK EDUCATIONAL PRODUCT



PRODUCED BY AN AUTODESK EDUCATIONAL PRODUCT


The contents of this Drawing are the sole property of C&S ELECTRIC LTD.
and they should neither be copied nor given to a third person without the prior permission of Company

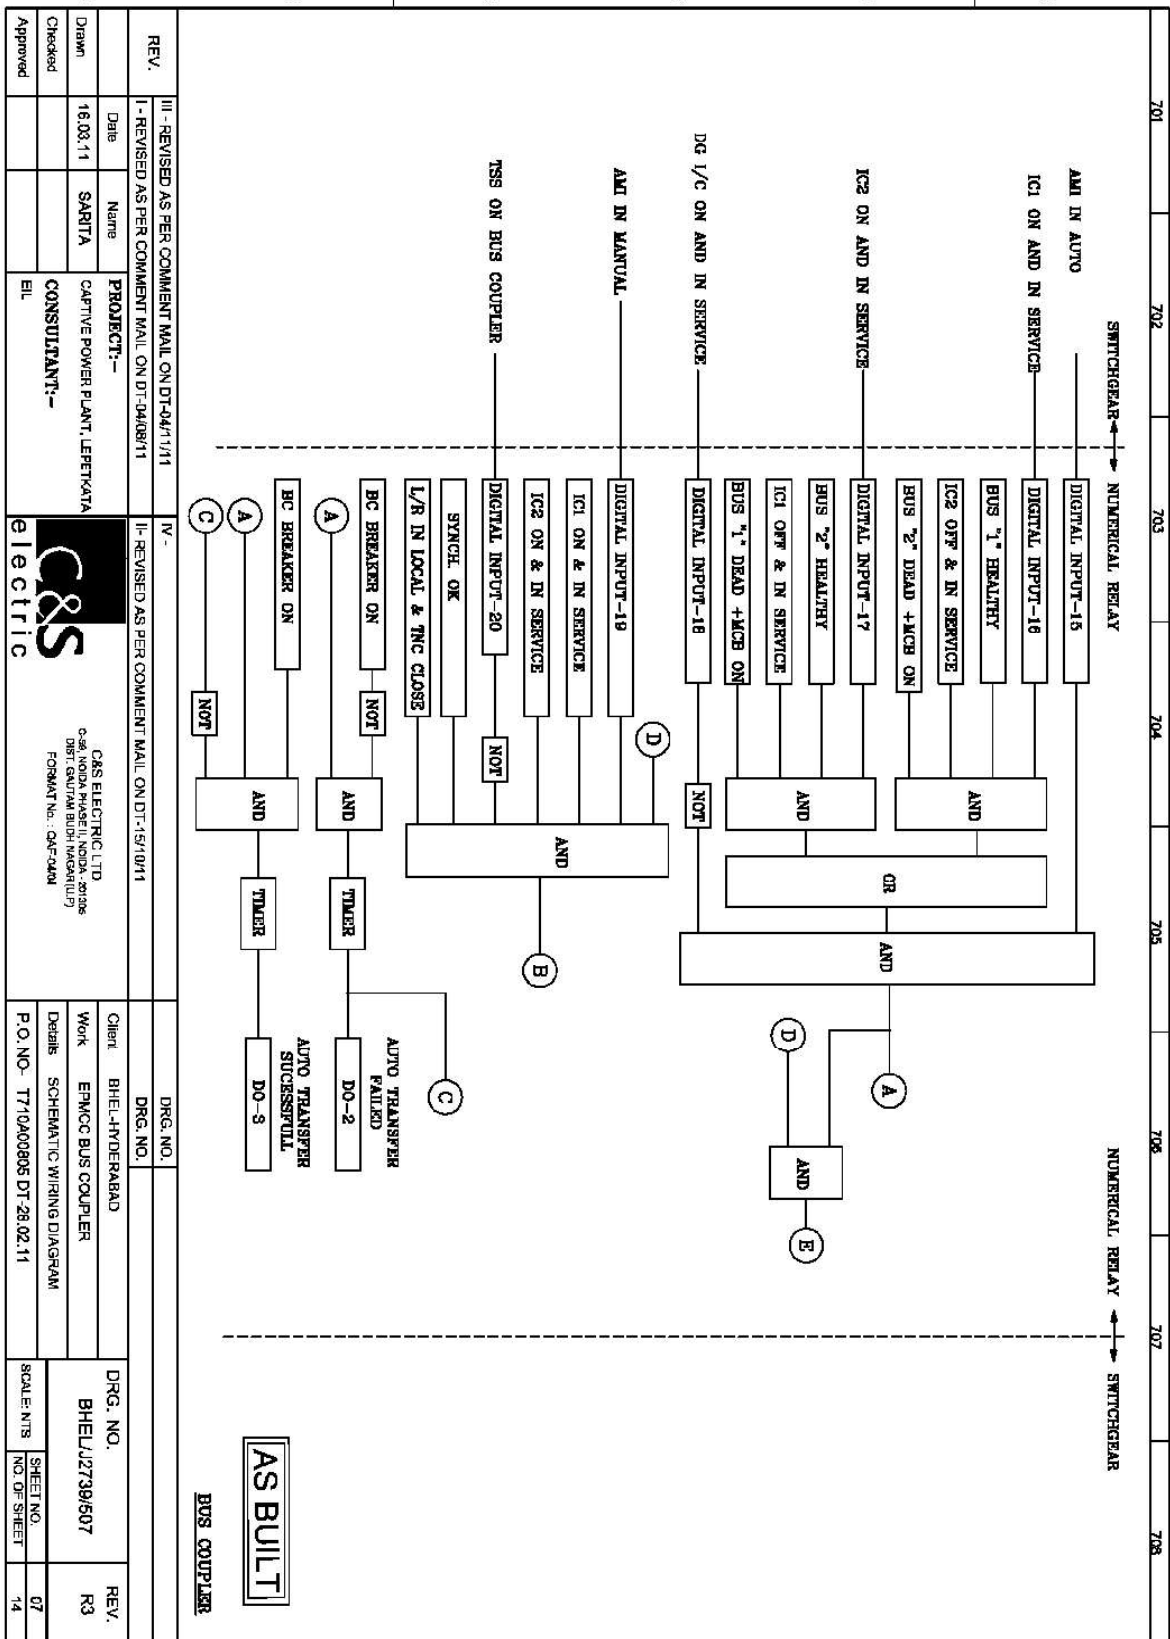


PRODUCED BY AN AUTODESK EDUCATIONAL PRODUCT

PRODUCED BY AN AUTODESK EDUCATIONAL PRODUCT

 PRODUCED BY AN AUTODESK EDUCATIONAL PRODUCT



PRODUCED BY AN AUTODESK EDUCATIONAL PRODUCT

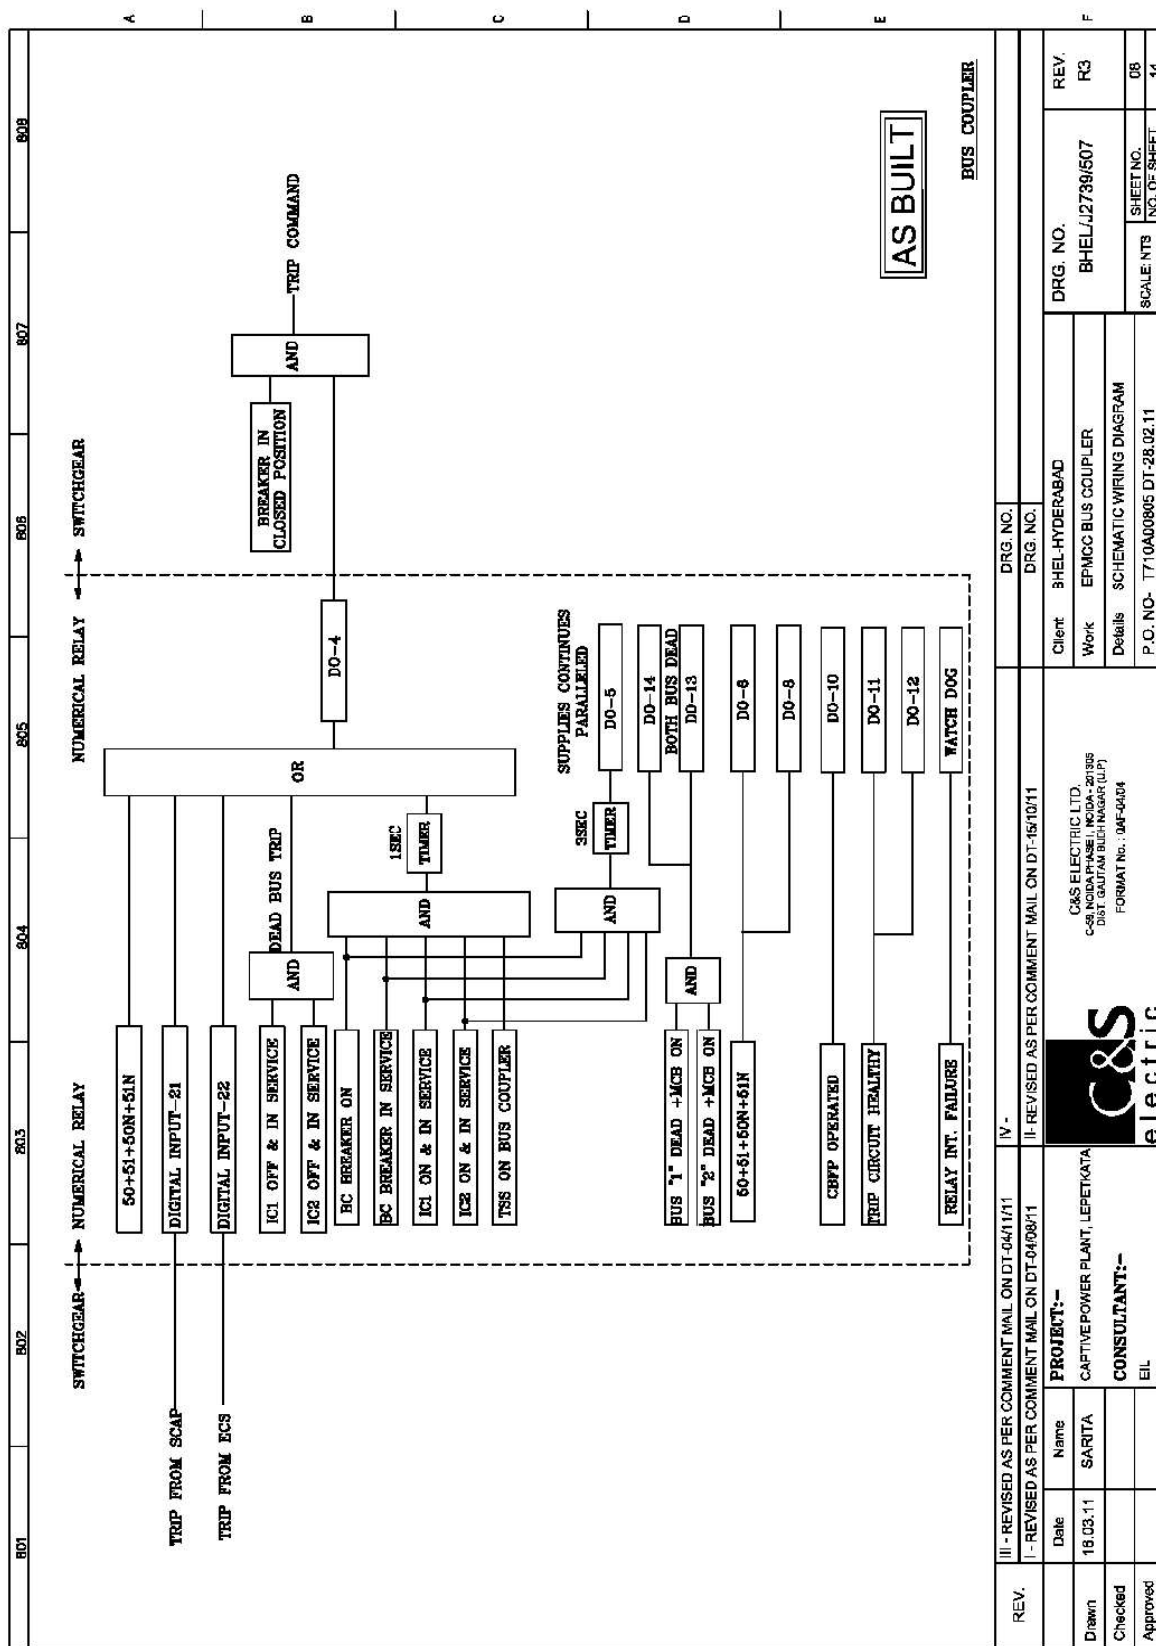

The contents of this Drawing are the sole property of C&S ELECTRIC LTD. and they should neither be copied nor given to a third person without the prior permission of Company.

PRODUCED BY AN AUTODESK EDUCATIONAL PRODUCT

PRODUCED BY AN AUTODESK EDUCATIONAL PRODUCT



PRODUCED BY AN AUTODESK EDUCATIONAL PRODUCT

PRODUCED BY AN AUTODESK EDUCATIONAL PRODUCT


901	902	903	904	905	907	908
PROTECTION FUNCTIONS						
3- PH INT./INT. O/C PROTECTION	3- PH INT./INT. O/C PROTECTION	3- PH INT./INT. O/C PROTECTION	3- PH INT./INT. O/C PROTECTION	3- PH INT./INT. O/C PROTECTION	3- PH INT./INT. O/C PROTECTION	3- PH INT./INT. O/C PROTECTION
3- PH INST./INT. O/C PROTECTION	3- PH INST./INT. O/C PROTECTION	3- PH INST./INT. O/C PROTECTION	3- PH INST./INT. O/C PROTECTION	3- PH INST./INT. O/C PROTECTION	3- PH INST./INT. O/C PROTECTION	3- PH INST./INT. O/C PROTECTION
INT./INT. E/F PROTECTION	INT./INT. E/F PROTECTION	INT./INT. E/F PROTECTION	INT./INT. E/F PROTECTION	INT./INT. E/F PROTECTION	INT./INT. E/F PROTECTION	INT./INT. E/F PROTECTION
INST./INT. E/F PROTECTION	INST./INT. E/F PROTECTION	INST./INT. E/F PROTECTION	INST./INT. E/F PROTECTION	INST./INT. E/F PROTECTION	INST./INT. E/F PROTECTION	INST./INT. E/F PROTECTION
CHECK SYNCHRONISING	CHECK SYNCHRONISING	CHECK SYNCHRONISING	CHECK SYNCHRONISING	CHECK SYNCHRONISING	CHECK SYNCHRONISING	CHECK SYNCHRONISING
CIRCUIT BREAKER FAILURE	CIRCUIT BREAKER FAILURE	CIRCUIT BREAKER FAILURE	CIRCUIT BREAKER FAILURE	CIRCUIT BREAKER FAILURE	CIRCUIT BREAKER FAILURE	CIRCUIT BREAKER FAILURE
MEASUREMENT FUNCTIONS						
3- PHASE CURRENT MEASUREMENT	3- PHASE CURRENT MEASUREMENT	3- PHASE CURRENT MEASUREMENT	3- PHASE CURRENT MEASUREMENT	3- PHASE CURRENT MEASUREMENT	3- PHASE CURRENT MEASUREMENT	3- PHASE CURRENT MEASUREMENT
NEUTRAL CURRENT MEASUREMENT	NEUTRAL CURRENT MEASUREMENT	NEUTRAL CURRENT MEASUREMENT	NEUTRAL CURRENT MEASUREMENT	NEUTRAL CURRENT MEASUREMENT	NEUTRAL CURRENT MEASUREMENT	NEUTRAL CURRENT MEASUREMENT
ACTIVE POWER MEASUREMENT	ACTIVE POWER MEASUREMENT	ACTIVE POWER MEASUREMENT	ACTIVE POWER MEASUREMENT	ACTIVE POWER MEASUREMENT	ACTIVE POWER MEASUREMENT	ACTIVE POWER MEASUREMENT
REACTIVE POWER MEASUREMENT	REACTIVE POWER MEASUREMENT	REACTIVE POWER MEASUREMENT	REACTIVE POWER MEASUREMENT	REACTIVE POWER MEASUREMENT	REACTIVE POWER MEASUREMENT	REACTIVE POWER MEASUREMENT
ENERGY MEASUREMENT	ENERGY MEASUREMENT	ENERGY MEASUREMENT	ENERGY MEASUREMENT	ENERGY MEASUREMENT	ENERGY MEASUREMENT	ENERGY MEASUREMENT
POWER FACTOR MEASUREMENT	POWER FACTOR MEASUREMENT	POWER FACTOR MEASUREMENT	POWER FACTOR MEASUREMENT	POWER FACTOR MEASUREMENT	POWER FACTOR MEASUREMENT	POWER FACTOR MEASUREMENT
CONDITION MONITORING FEATURES						
RELAY INTERNAL SELF SUPERVISION	RELAY INTERNAL SELF SUPERVISION	RELAY INTERNAL SELF SUPERVISION	RELAY INTERNAL SELF SUPERVISION	RELAY INTERNAL SELF SUPERVISION	RELAY INTERNAL SELF SUPERVISION	RELAY INTERNAL SELF SUPERVISION
TRIP CIRCUIT SUPERVISION	TRIP CIRCUIT SUPERVISION	TRIP CIRCUIT SUPERVISION	TRIP CIRCUIT SUPERVISION	TRIP CIRCUIT SUPERVISION	TRIP CIRCUIT SUPERVISION	TRIP CIRCUIT SUPERVISION
BREAKER CONDITION MONITORING	BREAKER CONDITION MONITORING	BREAKER CONDITION MONITORING	BREAKER CONDITION MONITORING	BREAKER CONDITION MONITORING	BREAKER CONDITION MONITORING	BREAKER CONDITION MONITORING
OTHER FUNCTIONS AVAILABLE IN RELAY						
CIRCUIT BREAKER CONTROL	CIRCUIT BREAKER CONTROL	CIRCUIT BREAKER CONTROL	CIRCUIT BREAKER CONTROL	CIRCUIT BREAKER CONTROL	CIRCUIT BREAKER CONTROL	CIRCUIT BREAKER CONTROL
DISTURBANCE RECORDING	DISTURBANCE RECORDING	DISTURBANCE RECORDING	DISTURBANCE RECORDING	DISTURBANCE RECORDING	DISTURBANCE RECORDING	DISTURBANCE RECORDING
FAULT RECORDING	FAULT RECORDING	FAULT RECORDING	FAULT RECORDING	FAULT RECORDING	FAULT RECORDING	FAULT RECORDING
EVENT RECORDING	EVENT RECORDING	EVENT RECORDING	EVENT RECORDING	EVENT RECORDING	EVENT RECORDING	EVENT RECORDING
DOUBLING FEATURE DURING STARTING	DOUBLING FEATURE DURING STARTING	DOUBLING FEATURE DURING STARTING	DOUBLING FEATURE DURING STARTING	DOUBLING FEATURE DURING STARTING	DOUBLING FEATURE DURING STARTING	DOUBLING FEATURE DURING STARTING
SIGNALS WIRING TO DI OF RELAY						
INPUT NO.	INPUT DESC.	SIGNAL DESCRIPTION	INPUT NO.	INPUT DESC.	SIGNAL DESCRIPTION	INPUT NO.
D-1	D11-F8	AMI IN INDEPENDENT	D-1	D11-F8	AMI IN INDEPENDENT	D-1
D-2	D12-D8	SW IN LOCAL & INC. CLOSE	D-2	D12-D8	SW IN LOCAL & INC. CLOSE	D-2
D-3	D13-D6	SW IN REMOTE & SOUP. CLOSE	D-3	D13-D6	SW IN REMOTE & SOUP. CLOSE	D-3
D-4	D14-D4	SW IN REMOTE & EDS CLOSE	D-4	D14-D4	SW IN REMOTE & EDS CLOSE	D-4
D-5	D15-D2	BUSCOUPLER ON	D-5	D15-D2	BUSCOUPLER ON	D-5
D-6	D16-D12	BUSCOUPLER IN SERVICE	D-6	D16-D12	BUSCOUPLER IN SERVICE	D-6
D-7	D17-F10	BREAKER SPRING CHARGED	D-7	D17-F10	BREAKER SPRING CHARGED	D-7
D-8	D18-D16	I/C-1 OFF AND IN SERVICE	D-8	D18-D16	I/C-1 OFF AND IN SERVICE	D-8
D-9	D19-F14	BUS-2 HEALTHY	D-9	D19-F14	BUS-2 HEALTHY	D-9
D-10	D10-E2	BUS "1" DEAD (<40%) AND BUS PT-A MCS ON	D-10	D10-E2	BUS "1" DEAD (<40%) AND BUS PT-A MCS ON	D-10
D-11	D11-F2	I/C-2 OFF AND IN SERVICE	D-11	D11-F2	I/C-2 OFF AND IN SERVICE	D-11
D-12	D12-E4	BUS-1 HEALTHY	D-12	D12-E4	BUS-1 HEALTHY	D-12
D-13	D13-E6	BUS "2" DEAD (<40%) AND BUS PT-B MCS ON	D-13	D13-E6	BUS "2" DEAD (<40%) AND BUS PT-B MCS ON	D-13
D-14	D14-E12	BREAKER IN TEST	D-14	D14-E12	BREAKER IN TEST	D-14
D-15	D15-F4	AMI IN AUTO	D-15	D15-F4	AMI IN AUTO	D-15
D-16	D16-F18	I/C-1 ON AND IN SERVICE	D-16	D16-F18	I/C-1 ON AND IN SERVICE	D-16
D-17	D17-E8	I/C-2 ON AND IN SERVICE	D-17	D17-E8	I/C-2 ON AND IN SERVICE	D-17
D-18	D18-E14	DS I/C ON AND IN SERVICE	D-18	D18-E14	DS I/C ON AND IN SERVICE	D-18
D-19	D19-F6	AMI IN MANUAL	D-19	D19-F6	AMI IN MANUAL	D-19
D-20	D20-F12	TSS ON BUSCOUPLER	D-20	D20-F12	TSS ON BUSCOUPLER	D-20
D-21	D21-E10	TRIP FROM SOUP	D-21	D21-E10	TRIP FROM SOUP	D-21
D-22	D22-D14	TRIP FROM EDS	D-22	D22-D14	TRIP FROM EDS	D-22
RELAY COMMUNICATION DETAILS						
FRONT COMMUNICATION PORT	RS232C	FRONT COMMUNICATION PORT	RS232C	FRONT COMMUNICATION PORT	RS232C	FRONT COMMUNICATION PORT
REAR COMMUNICATION PORT	RS485	REAR COMMUNICATION PORT	RS485	REAR COMMUNICATION PORT	RS485	REAR COMMUNICATION PORT
COMMUNICATION PROTOCOL	IEC-61850	COMMUNICATION PROTOCOL	IEC-61850	COMMUNICATION PROTOCOL	IEC-61850	COMMUNICATION PROTOCOL
OUTPUT CONTACT OF RELAY						
OUTPUT NO.	SIGNAL DESCRIPTION	OUTPUT NO.	SIGNAL DESCRIPTION	OUTPUT NO.	SIGNAL DESCRIPTION	OUTPUT NO.
J13, J14	WATCH DOG	J13, J14	WATCH DOG	J13, J14	WATCH DOG	J13, J14
H1, H2	TRIP CIRCUIT MONITORING	H1, H2	TRIP CIRCUIT MONITORING	H1, H2	TRIP CIRCUIT MONITORING	H1, H2
H3, H4	FAULT TRIP	H3, H4	FAULT TRIP	H3, H4	FAULT TRIP	H3, H4
H5, H6	TRIP COMMAND	H5, H6	TRIP COMMAND	H5, H6	TRIP COMMAND	H5, H6
H6, H8	DS CLOSE COMMAND	H6, H8	DS CLOSE COMMAND	H6, H8	DS CLOSE COMMAND	H6, H8
H11, H12	BS OPERATED F/B TO EDS	H11, H12	BS OPERATED F/B TO EDS	H11, H12	BS OPERATED F/B TO EDS	H11, H12
H14, H15	SPARE CONTACT	H14, H15	SPARE CONTACT	H14, H15	SPARE CONTACT	H14, H15
H17, H18	TCS HEALTHY	H17, H18	TCS HEALTHY	H17, H18	TCS HEALTHY	H17, H18
G1, G2	SPARE CONTACT	G1, G2	SPARE CONTACT	G1, G2	SPARE CONTACT	G1, G2
G3, G4	SPARE CONTACT	G3, G4	SPARE CONTACT	G3, G4	SPARE CONTACT	G3, G4
G5, G6	AUTO CHANGE OVER BLOCKED	G5, G6	AUTO CHANGE OVER BLOCKED	G5, G6	AUTO CHANGE OVER BLOCKED	G5, G6
G8, G9	AUTO CHANGE OVER COMPLETED	G8, G9	AUTO CHANGE OVER COMPLETED	G8, G9	AUTO CHANGE OVER COMPLETED	G8, G9
G11, G12	SUPPLY REPAIRED	G11, G12	SUPPLY REPAIRED	G11, G12	SUPPLY REPAIRED	G11, G12
G14, G15	PMCC BOTH DEAD BUS TO INCLUDE I/C	G14, G15	PMCC BOTH DEAD BUS TO INCLUDE I/C	G14, G15	PMCC BOTH DEAD BUS TO INCLUDE I/C	G14, G15
G17, G18	TRIP OKT. UNHEALTHY	G17, G18	TRIP OKT. UNHEALTHY	G17, G18	TRIP OKT. UNHEALTHY	G17, G18
B1, B2	SPARE CONTACT	B1, B2	SPARE CONTACT	B1, B2	SPARE CONTACT	B1, B2
B3, B4	SPARE CONTACT	B3, B4	SPARE CONTACT	B3, B4	SPARE CONTACT	B3, B4
B5, B6	SPARE CONTACT	B5, B6	SPARE CONTACT	B5, B6	SPARE CONTACT	B5, B6
B7, B8	SPARE CONTACT	B7, B8	SPARE CONTACT	B7, B8	SPARE CONTACT	B7, B8
B9, B10	SPARE CONTACT	B9, B10	SPARE CONTACT	B9, B10	SPARE CONTACT	B9, B10
B11, B12	TRIP ON AMF TO I/C-1	B11, B12	TRIP ON AMF TO I/C-1	B11, B12	TRIP ON AMF TO I/C-1	B11, B12
B14, B15	TRIP ON AMF TO I/C-2	B14, B15	TRIP ON AMF TO I/C-2	B14, B15	TRIP ON AMF TO I/C-2	B14, B15
B17, B18	AMF SIGNAL TO DS AMF PANEL	B17, B18	AMF SIGNAL TO DS AMF PANEL	B17, B18	AMF SIGNAL TO DS AMF PANEL	B17, B18
AS BUILT						
BUS COUPLER						
REV. III - REVISED AS PER COMMENT MAIL ON DT-04/11/11						
REV. II - REVISED AS PER COMMENT MAIL ON DT-15/10/11						
REV. I - REVISED AS PER COMMENT MAIL ON DT-04/08/11						
PROJECT: - CAPTIVE POWER PLANT, LEPETKATA						
CONSULTANT: - EIL						
DATE: 16.03.11						
SARITA						
CHECKED: -						
APPROVED: -						
SCALE: NTS						
SHEET NO. 09						
NO. OF SHEET 14						
DRG. NO. BHEL/J2739/507						
REV. R3						
SCHEMATIC WIRING DIAGRAM						
P.O. NO. T710A00005 DT-28.02.11						
Client BHEL-HYDERABAD						
Work EPMCC BUS COUPLER						
Details SCHEMATIC WIRING DIAGRAM						
C&S ELECTRIC LTD.						
C-85, NODA PHASE I NODA - 20136						
DIST. GAUTAM BUDDH NAGAR (UP)						
FORMAT No : DAF-0404						

PRODUCED BY AN AUTODESK EDUCATIONAL PRODUCT

PRODUCED BY AN AUTODESK EDUCATIONAL PRODUCT


PRODUCED BY AN AUTODESK EDUCATIONAL PRODUCT

PRODUCED BY AN AUTODESK EDUCATIONAL PRODUCT

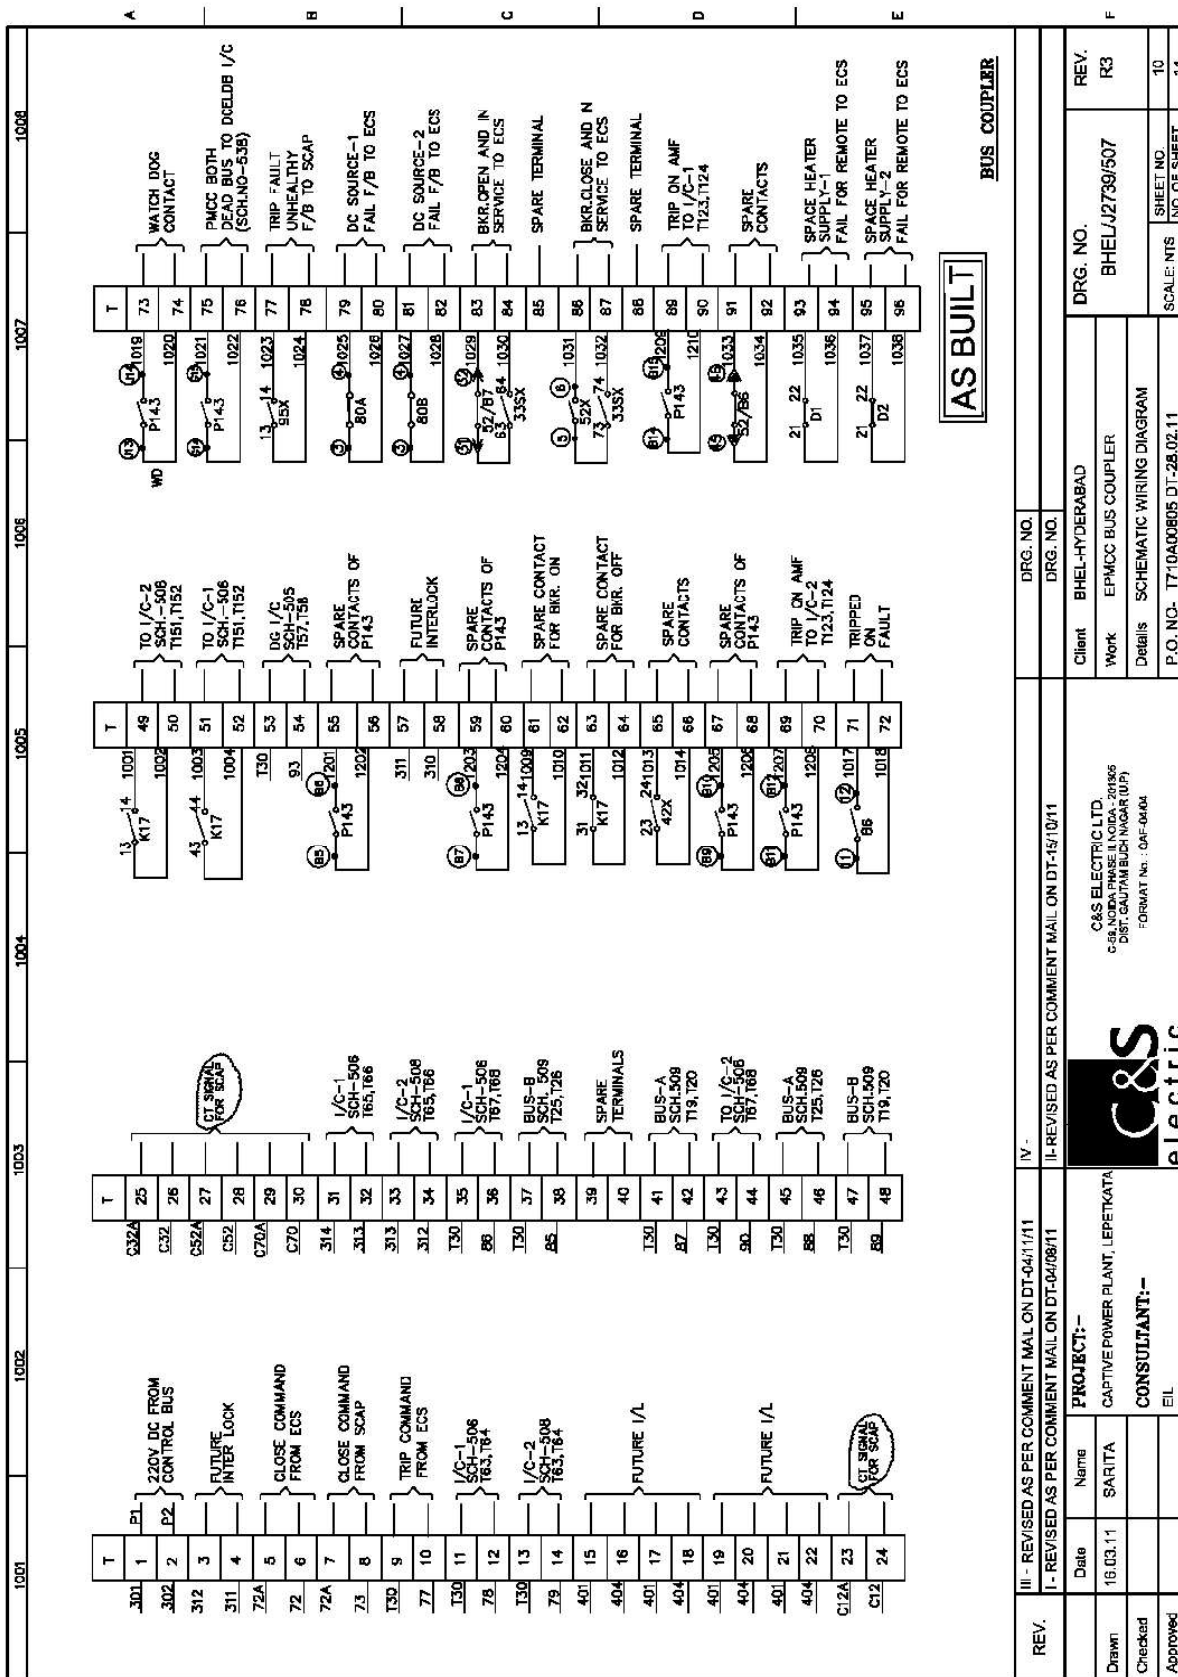


PRODUCED BY AN AUTODESK EDUCATIONAL PRODUCT

 PRODUCED BY AN AUTODESK EDUCATIONAL PRODUCT



PRODUCED BY AN AUTODESK EDUCATIONAL PRODUCT

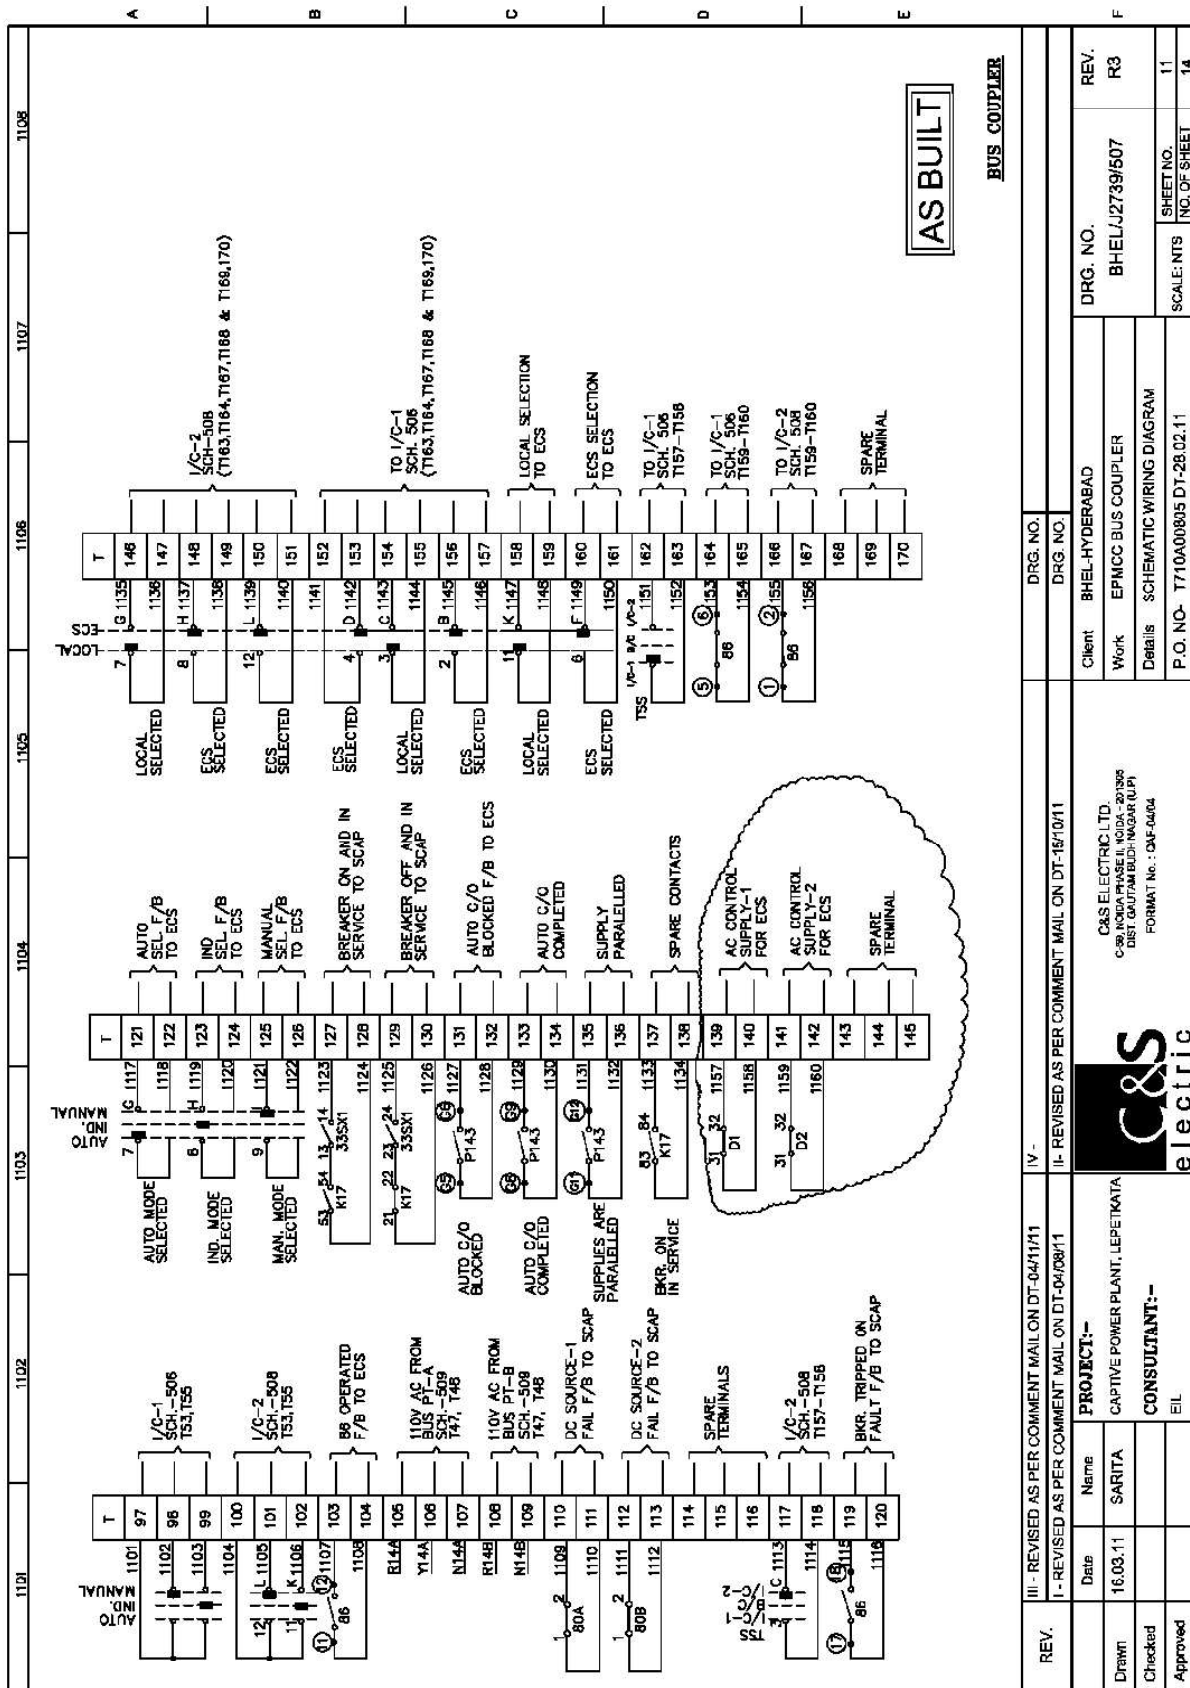


PRODUCED BY AN AUTODESK EDUCATIONAL PRODUCT




PRODUCED BY AN AUTODESK EDUCATIONAL PRODUCT

PRODUCED BY AN AUTODESK EDUCATIONAL PRODUCT

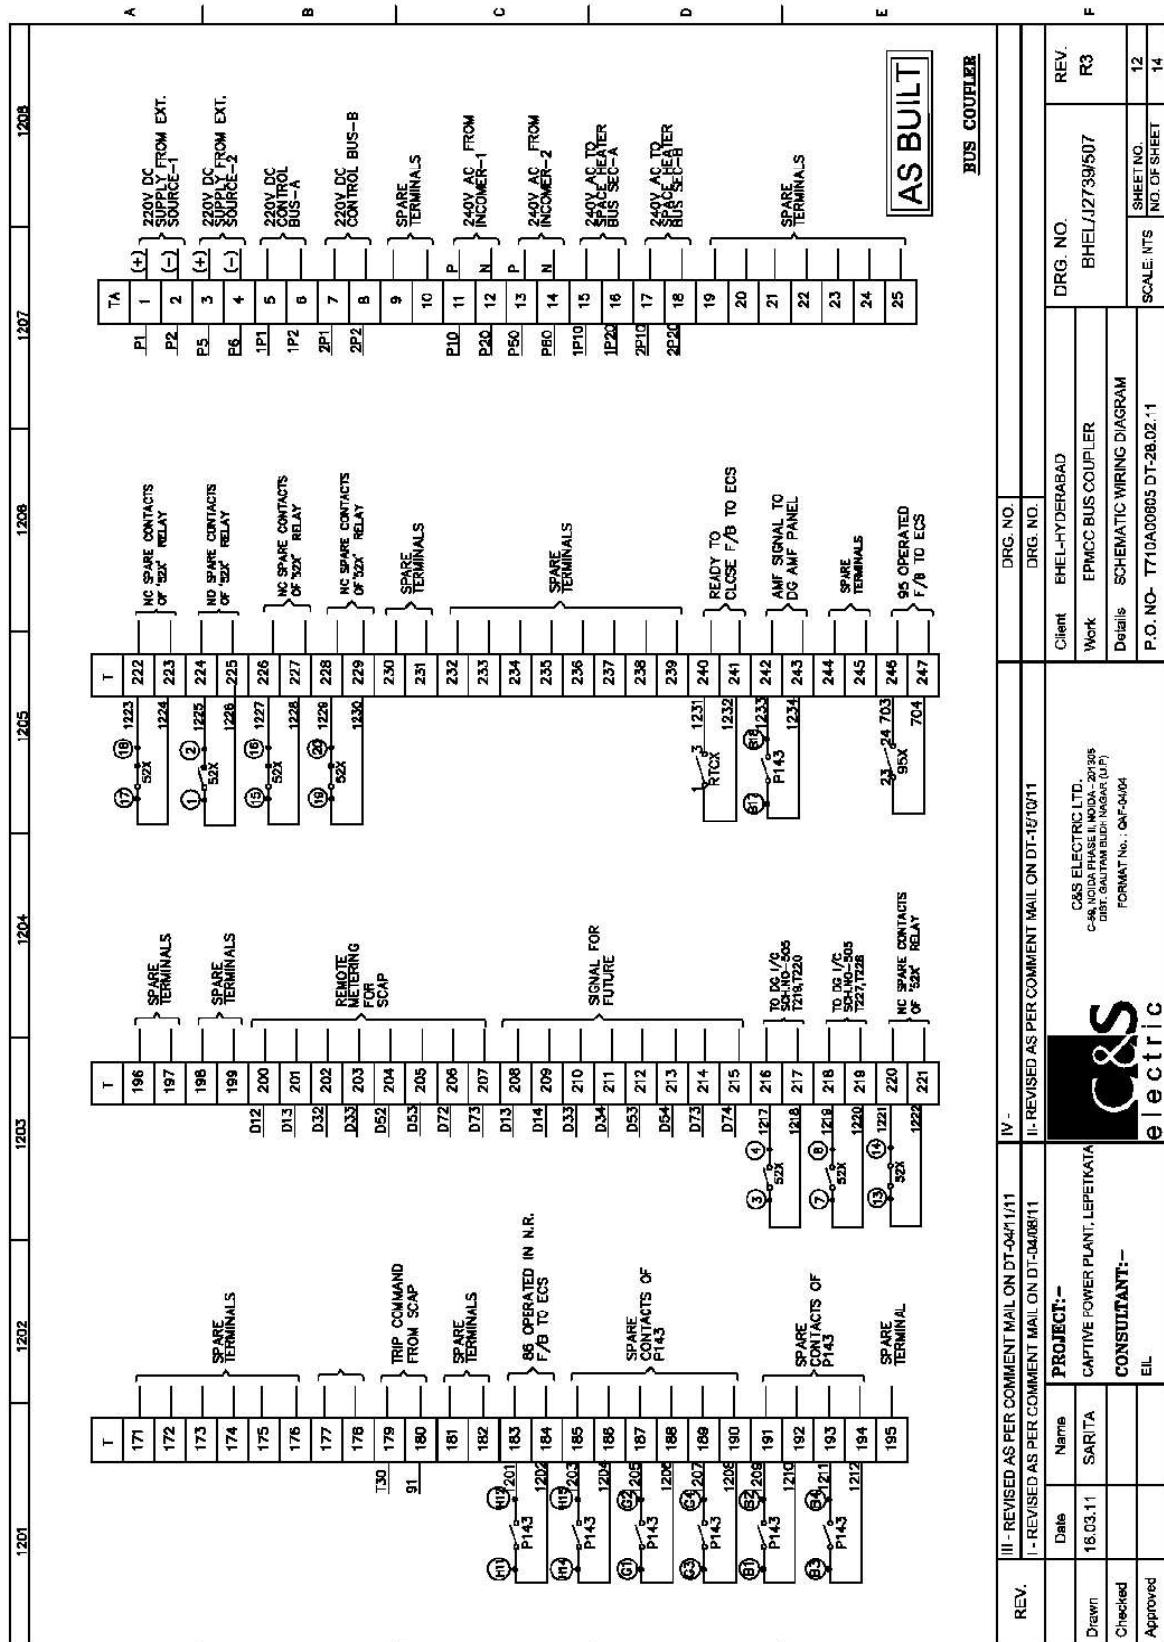


PRODUCED BY AN AUTODESK EDUCATIONAL PRODUCT

 PRODUCED BY AN AUTODESK EDUCATIONAL PRODUCT



PRODUCED BY AN AUTODESK EDUCATIONAL PRODUCT

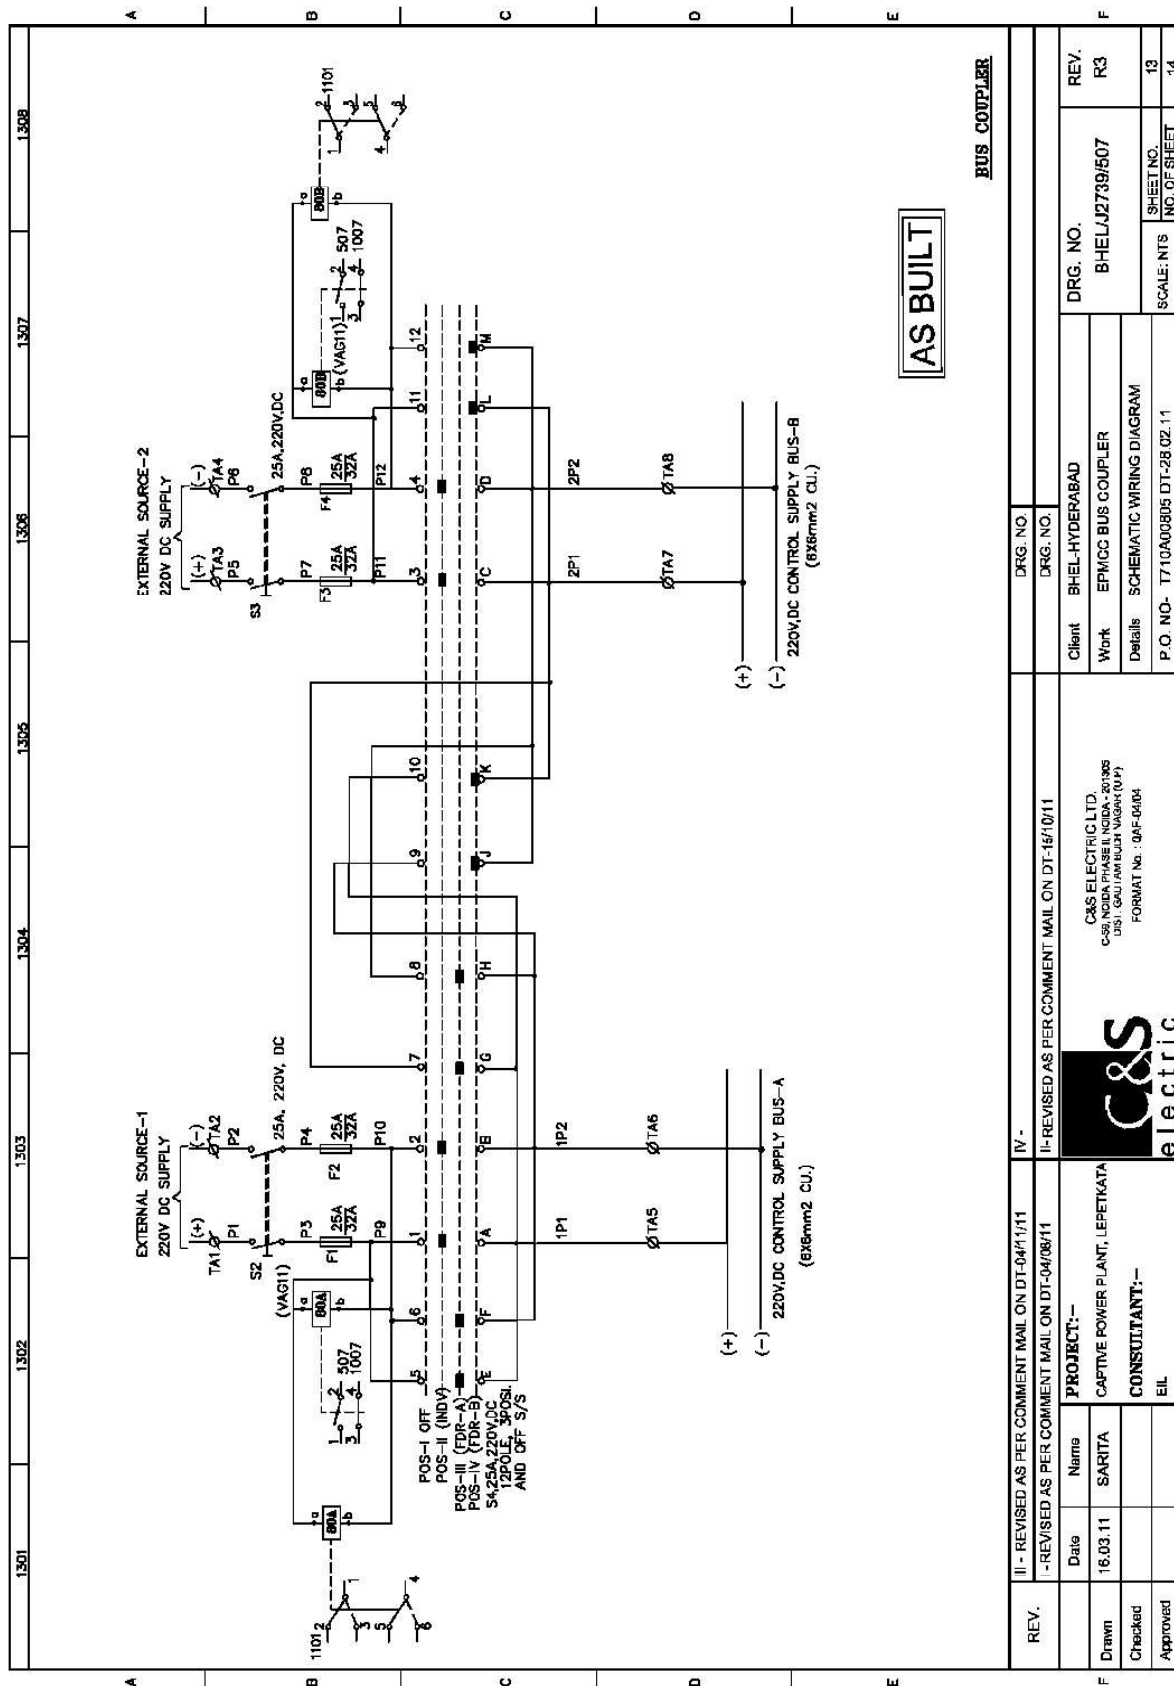


PRODUCED BY AN AUTODESK EDUCATIONAL PRODUCT

PRODUCED BY AN AUTODESK EDUCATIONAL PRODUCT



PRODUCED BY AN AUTODESK EDUCATIONAL PRODUCT

PRODUCED BY AN AUTODESK EDUCATIONAL PRODUCT

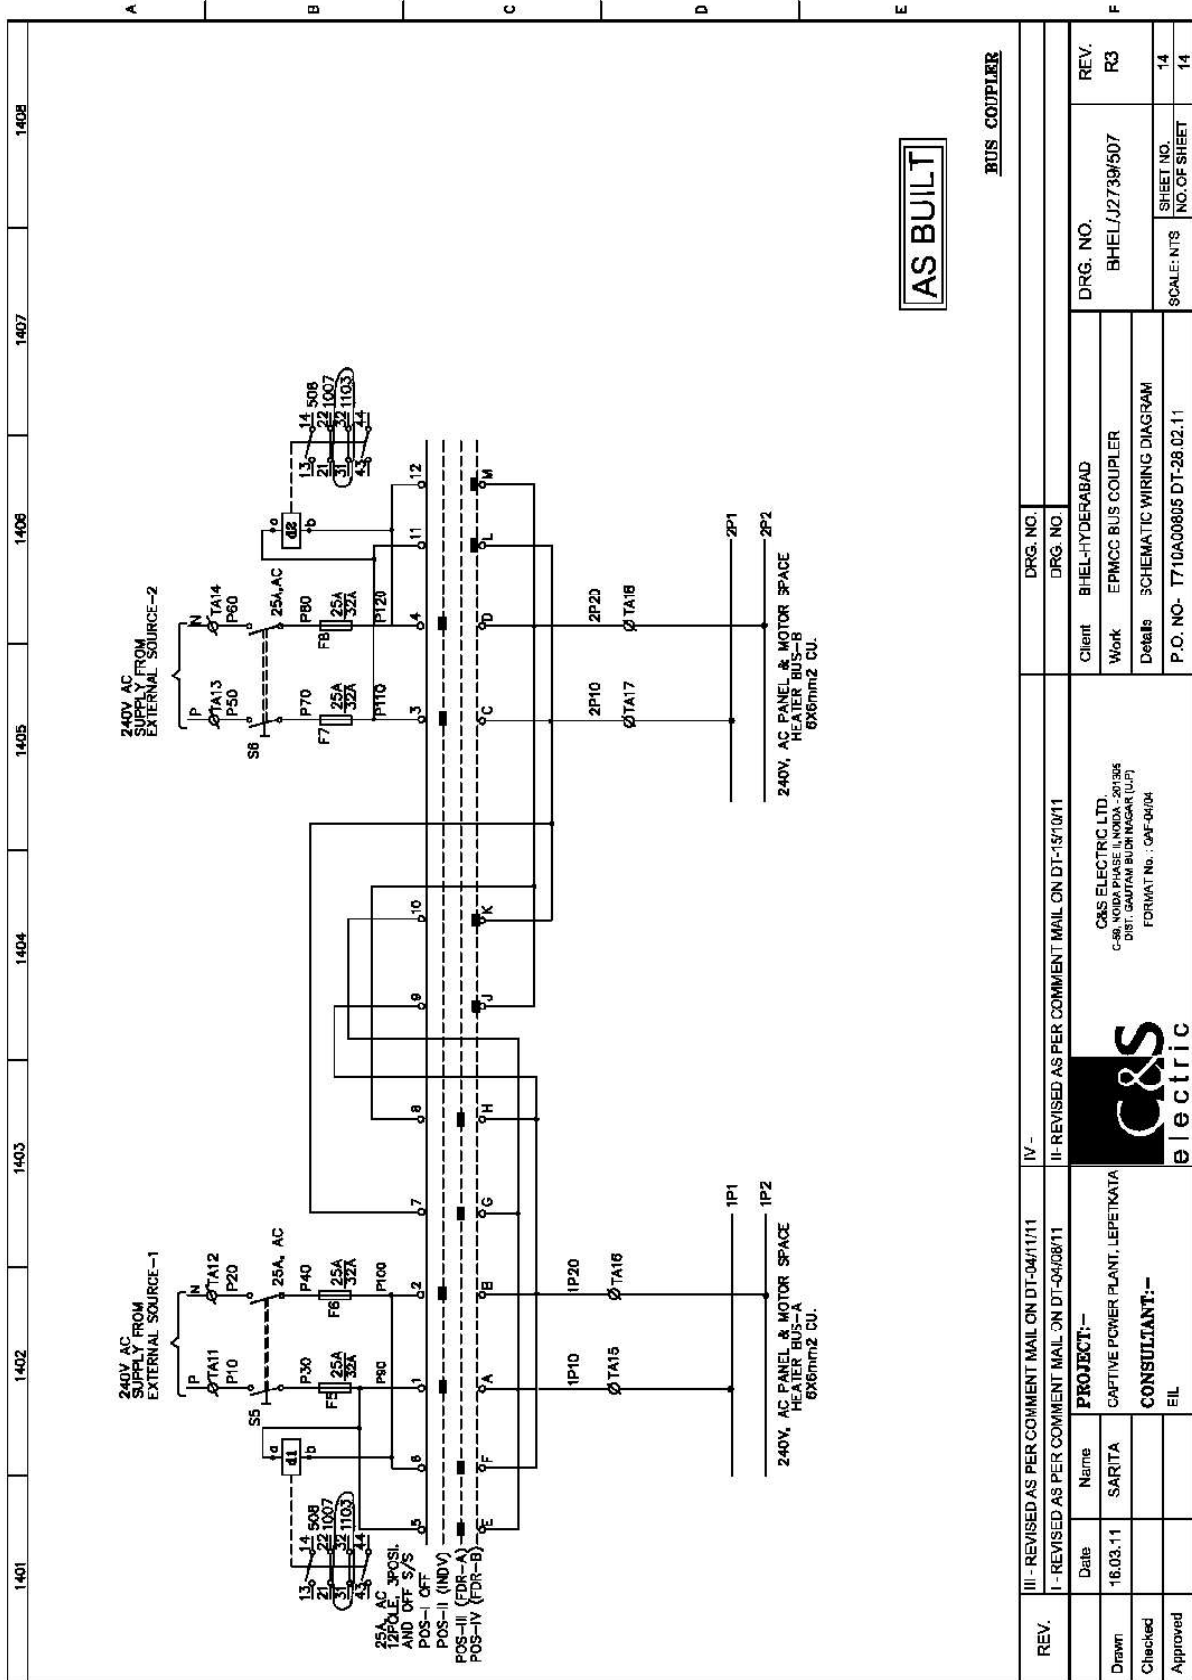

The contents of this Drawing are the sole property of C&S ELECTRIC LTD. and they should neither be copied nor given to a third person without the prior permission of Company

PRODUCED BY AN AUTODESK EDUCATIONAL PRODUCT

PRODUCED BY AN AUTODESK EDUCATIONAL PRODUCT