


The drawing, design and details given on this format are the property of ENGINEERS INDIA LIMITED. They are merely loaned on the borrower's express agreement that they will not be reproduced, copied, exhibited or used, except in the limited way permitted by a written consent given by the lender to the borrower for the intended use.

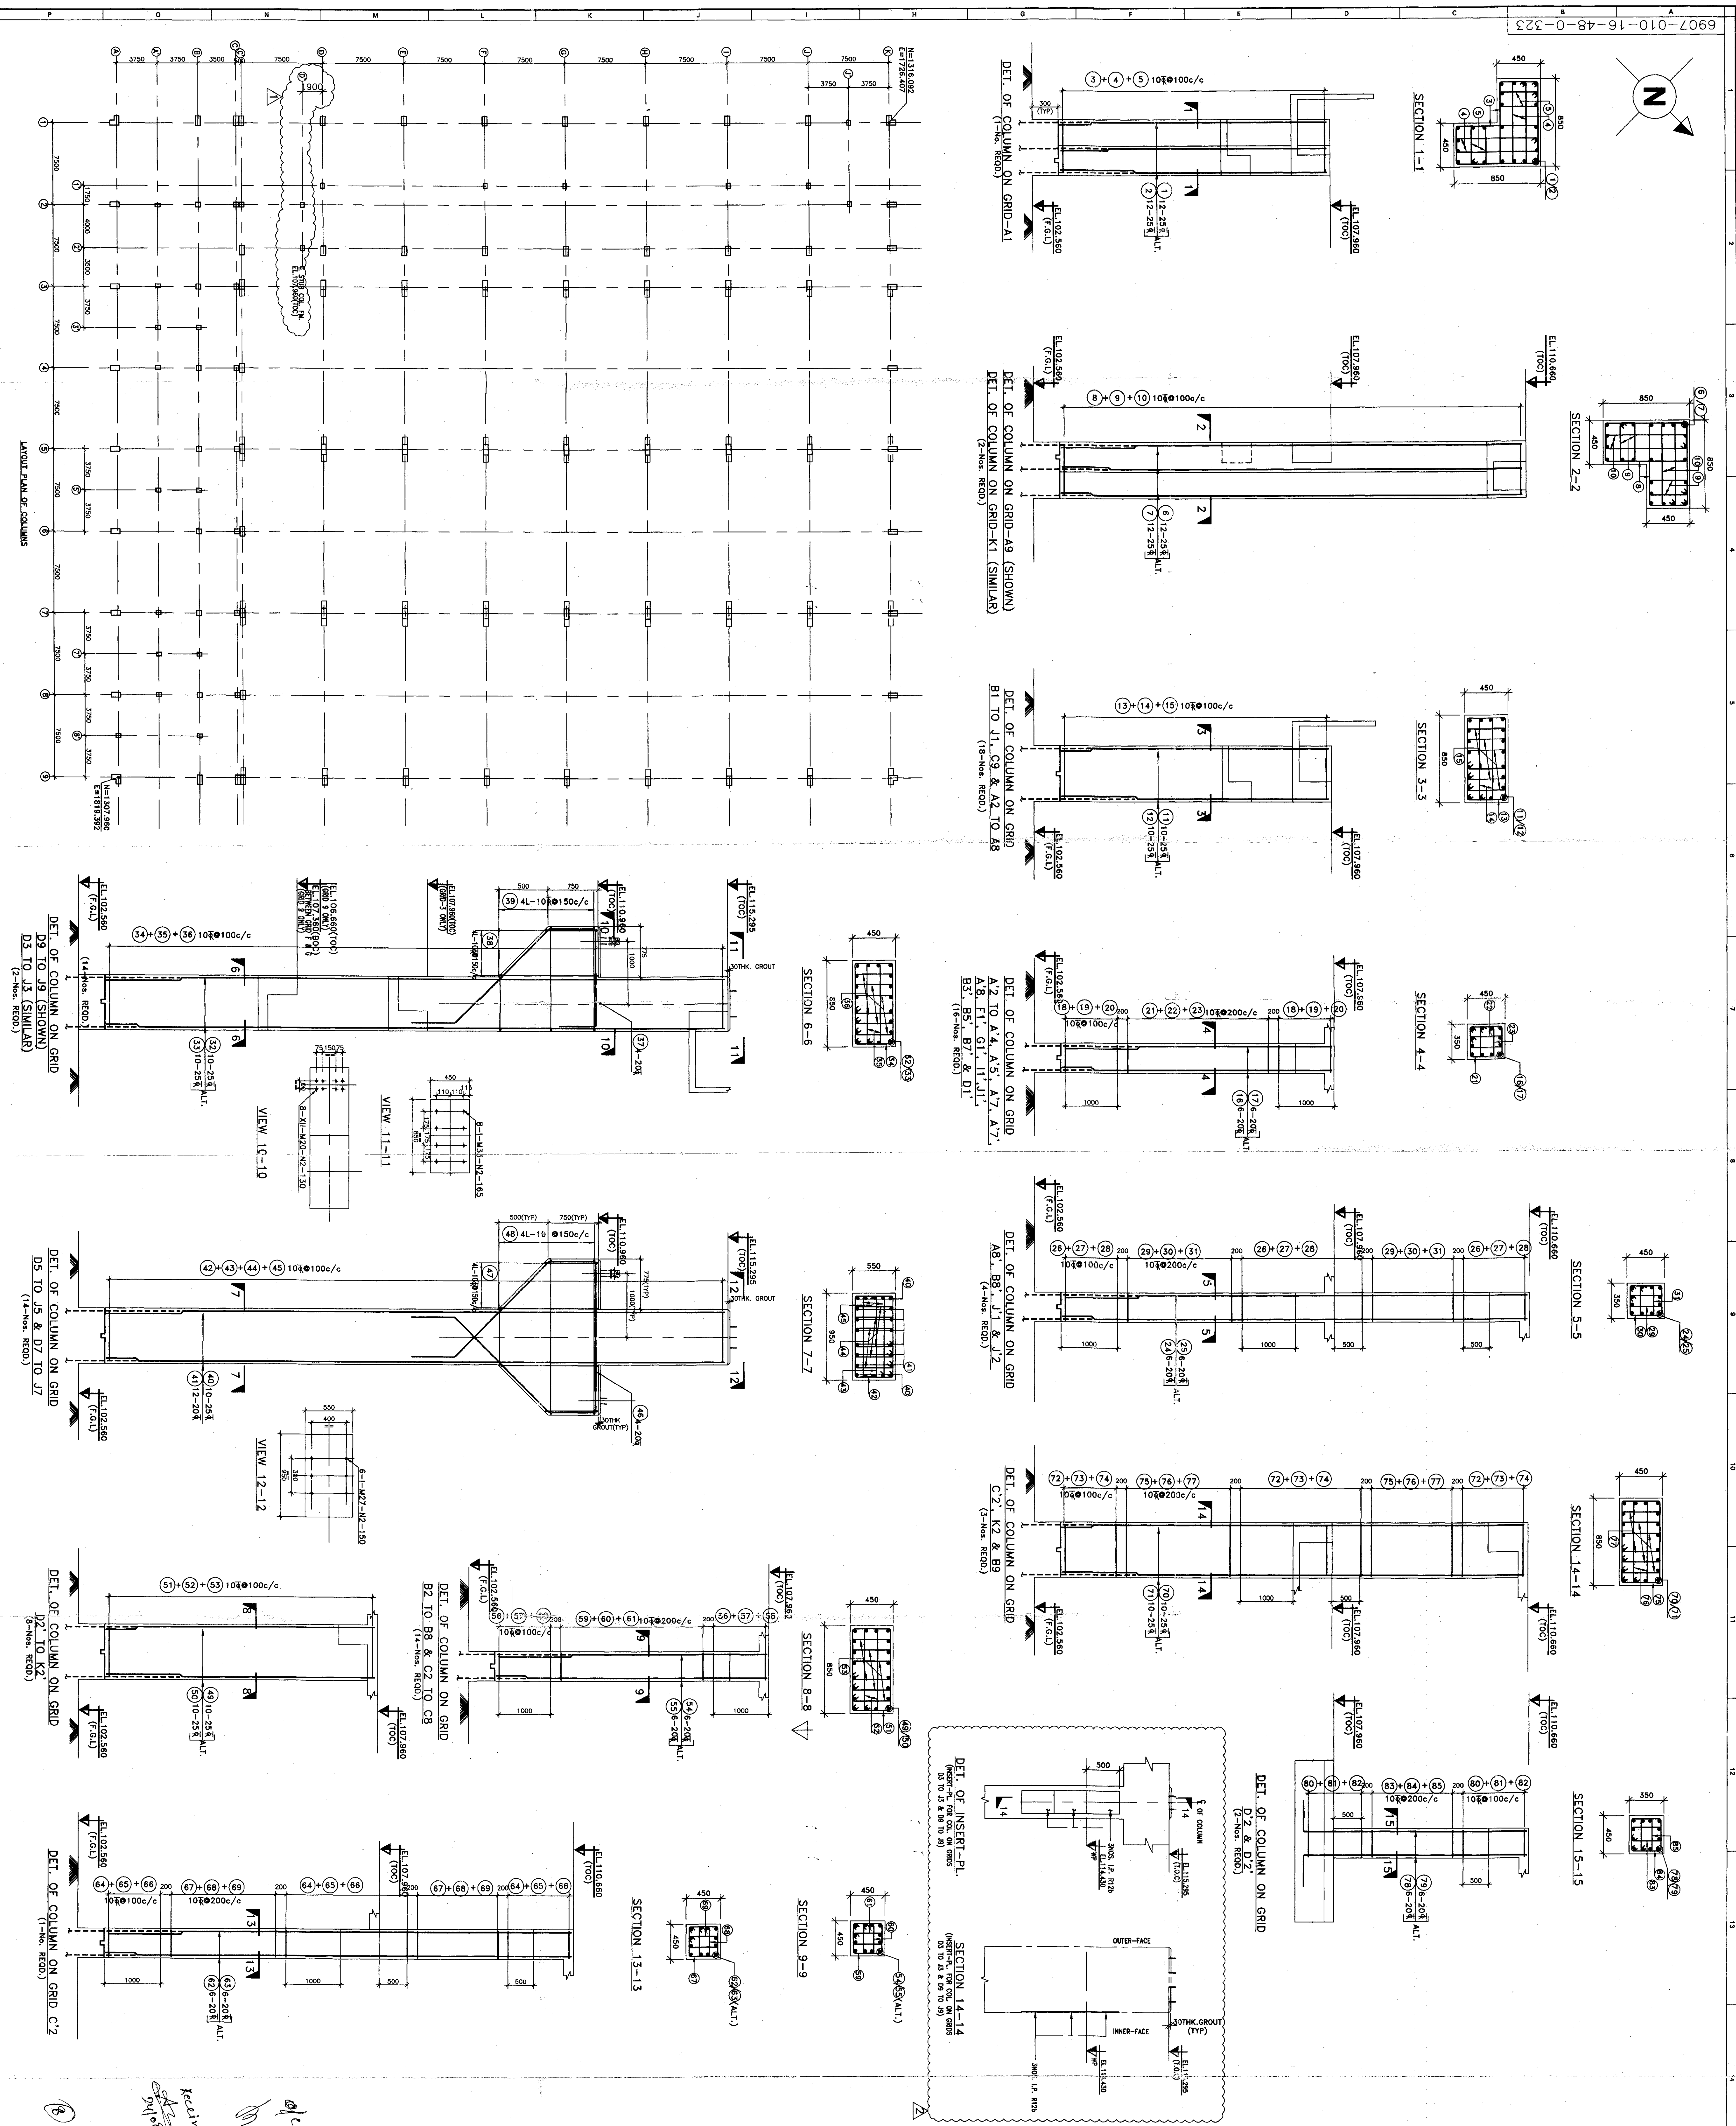

REF. DWG. NO.	REFERENCE DRAWING TITLE
15	16
8907-010-16-44-3-156	CENTRAL WORKSHOP- GROUND FLOOR PLAN
8907-010-16-44-3-191	CENTRAL WORKSHOP -ELEVATIONS & SECTION
8907-010-16-44-3-191	CENTRAL WORKSHOP- TERRACE FLOOR PLAN

1. ALL DIMENSION ARE IN mm AND LEVELS ARE IN M.
2. FOR GENERAL NOTES REFER DWG. NO. 6907-000-16-48-1-251
3. ALL ELEVATIONS CORRESPOND TO ABSOLUTE R.L.S.
4. CONC. GRADE SHALL BE M20, AS PER SPECIFICATION
5. REINFORCEMENT SHALL BE MSØ (GRADE F4+15)
CONFORMING TO IS:1786.
6. THIS Dwg SHALL BE READ IN CONJUNCTION WITH DWG. No.
6907-010-16-48-0-321.

FOR COLUMNS ON GRID K3 TO K9 & C13 TO C19
REFER DRG. No. 6907-10-16-48-0-326

GRADE OF CONCRETE - M30
APPROX. QUANTITY:- CONC. M30. = 1100.00m ³ HYD BARS = AS/BBS AS BUILT DRG

Sl. No.	Page No.	Page Date	Page Time	Page Unit
1	2	3	4	5

(A) Joint Venture Company of OMR (India) Ltd., OIL, NER & Coal of Assam) ब्रह्मपुत्र पेट्रोकेमिकल कॉम्पलैक्स लेपेटकाटा, डिब्रुगढ़, असम पेट्रोल क्लबिंग	BRAHMAPUTRA PETROCHEMICAL COMPLEX LEPETKATA, DIBRUGARH ASSAM CENTRAL WORKSHOP
---	--

SCALE	JOB NO.	UNIT	DEPT. SECT.	DWG. NO.	REV.
1:100	6 9 0 7	0 1 0	1 6 4 8	0 3 2 3	2
15				16	

1-1641-0500 REV. 0 A0-1189 x 841