



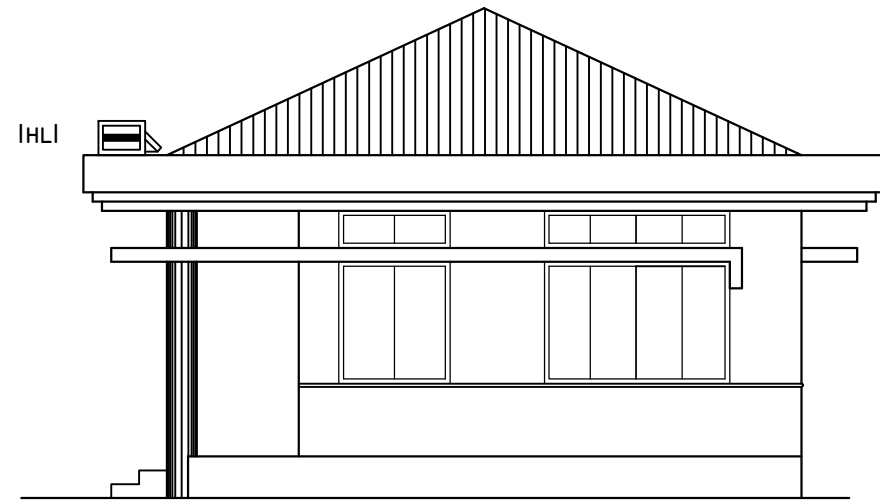


FRONT ELEVATION

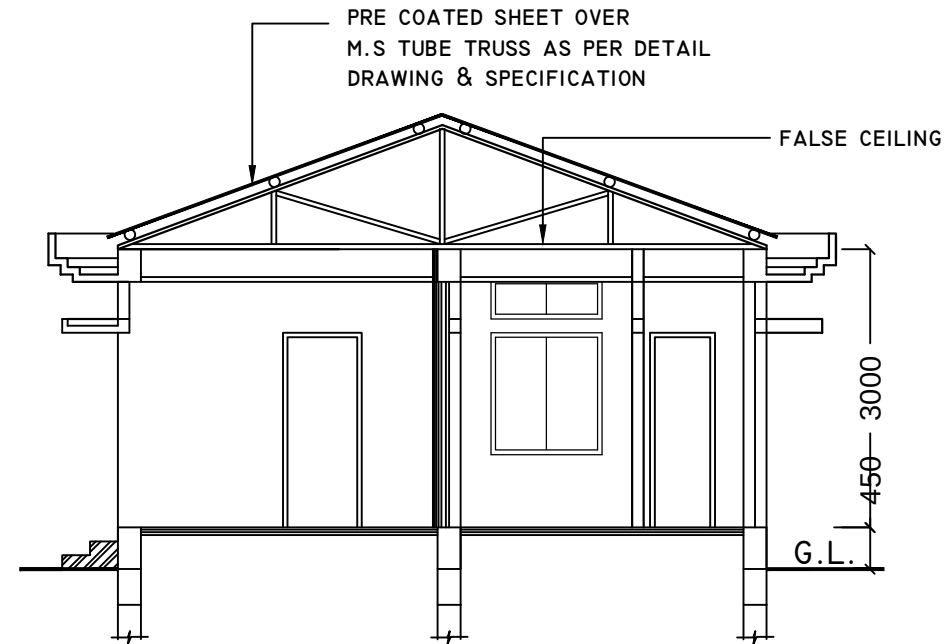

SECTION A-A

NOTE:
HALOGEN LAMP (HL) SHOULD BE FITTED FACING THE GATE

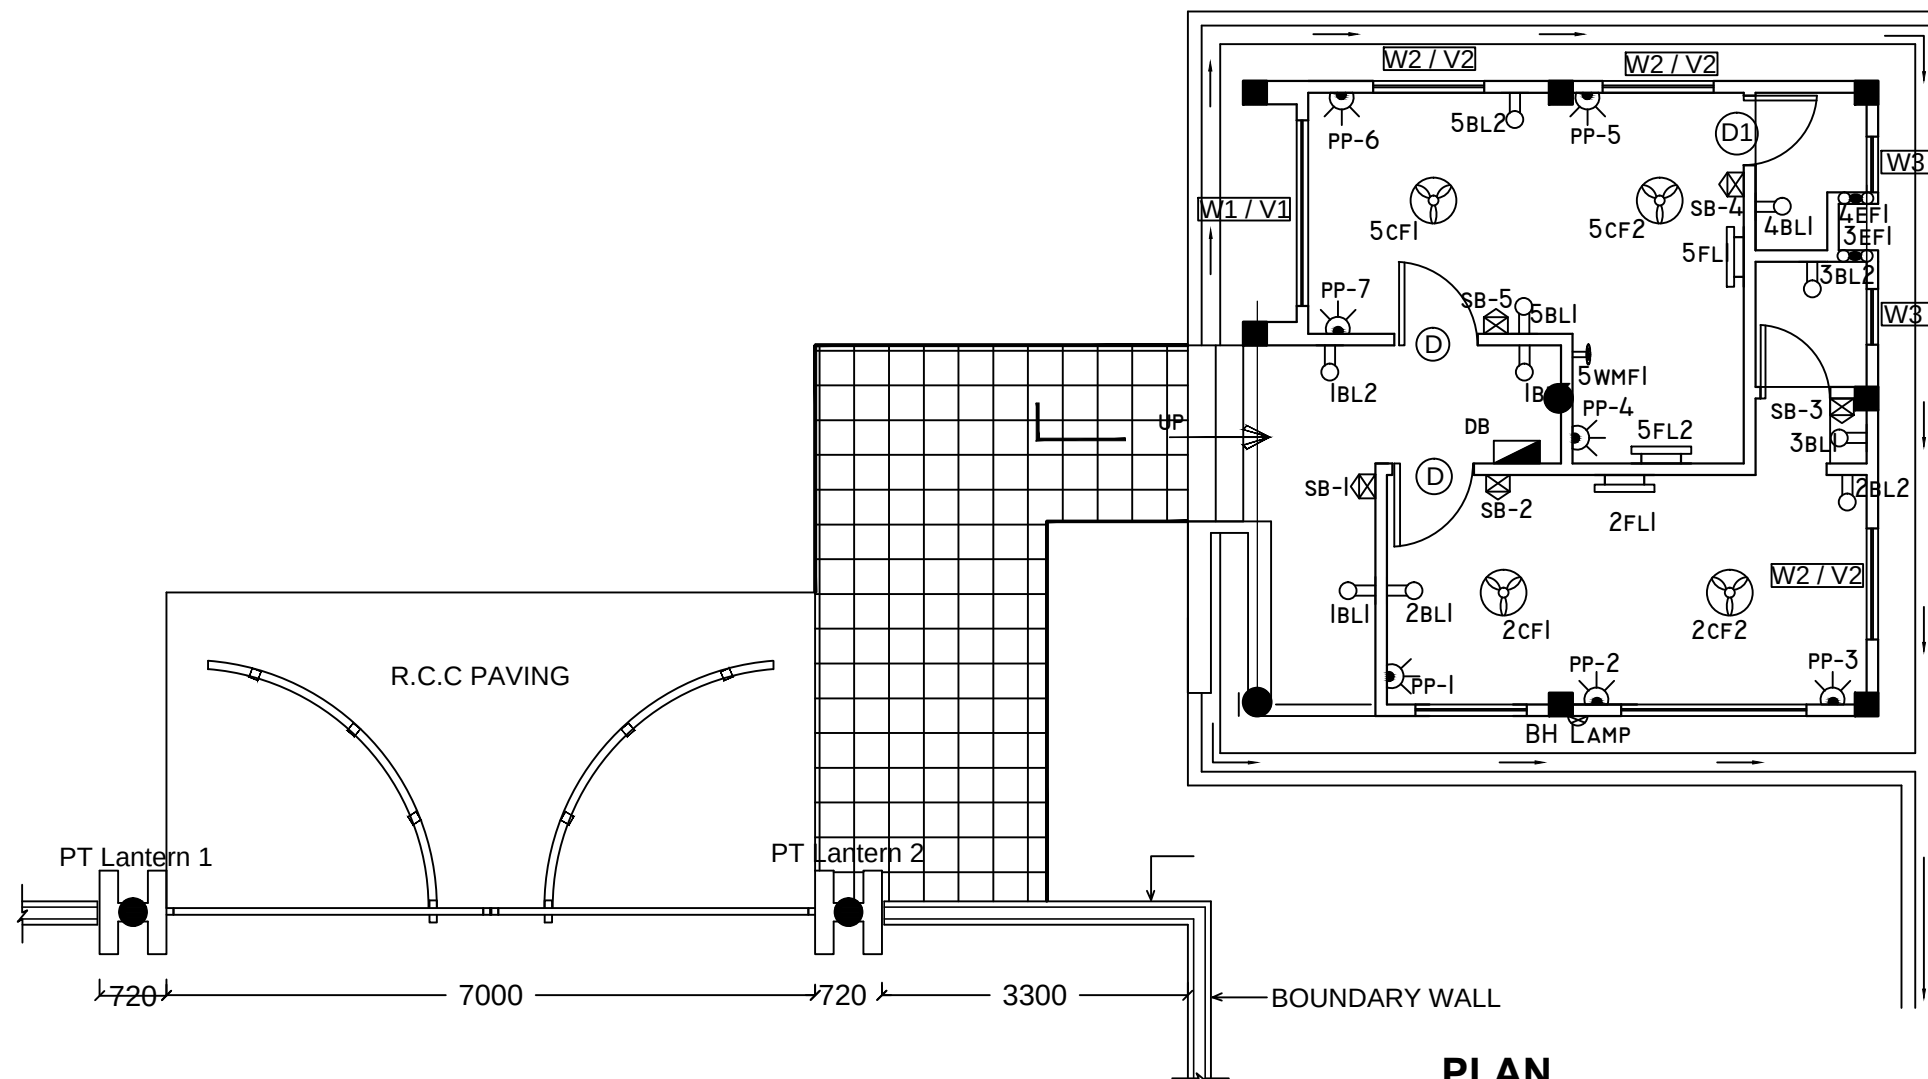

PLAN

Sl.No.	PARTICULAR	SYMBOL
1)	Distribution Board	
2)	Wall Bracket	
3)	Tube Light (Wall) (1X36 W)	
4)	Switch Board	
5)	Ceiling Fan	
6)	Exhaust Fan	
7)	Post Top lantern (PTL)	
8)	6/16 Amp plug pt.	
9)	Bulk Head Light	
10)	Halogen Lamp	

THIS DRAWING IS A COPYRIGHT.
CONTENTS OF THE DRAWING OR PART THEREOF
MAY NOT BE USED OR REPRODUCED WITHOUT
THE PERMISSION OF RAJKHOWAS AARCHI
M.D ROAD, CHANDMARI, GUWAHATI.

NOTES

- 1.ALL DIMENSIONS ARE TO BE READ AND NOT TO BE MEASURED.
- 2.ALL DIMENSIONS ARE IN MM UNLESS OTHERWISE SPECIFIED

S.NO.	REVISIONS	DATE
-------	-----------	------

REVISIONS

CLIENT

BRAHMAPUTRA CRACKER AND POLYMER LIMITED

PROJECT

CONSTRUCTION OF SECURITY OFFICE (2ND MAIN ENTRANCE GATE) FOR BCPL TOWNSHIP AT LEPETKATA, DIBRUGARH

SCALE :	JOB NO	10/GU/2008
	DEALT BY	
	CHECKED BY	

CLIENT'S SIGN

ARCHITECT'S SIGN

CONSULTANT

ARCHITECTS, ENGINEERS,
VALUERS & PLANNERS
M.D. ROAD, CHANDMARI
GUWAHATI-781003



DRAWING TITLE

ELECTRICAL LAYOUT
OF SECURITY OFFICE(2ND MAIN
ENTRANCE GATE)

DRAWING NO.

RAA /BCPL/SECURITY OFFICE/T/ELEC-01