



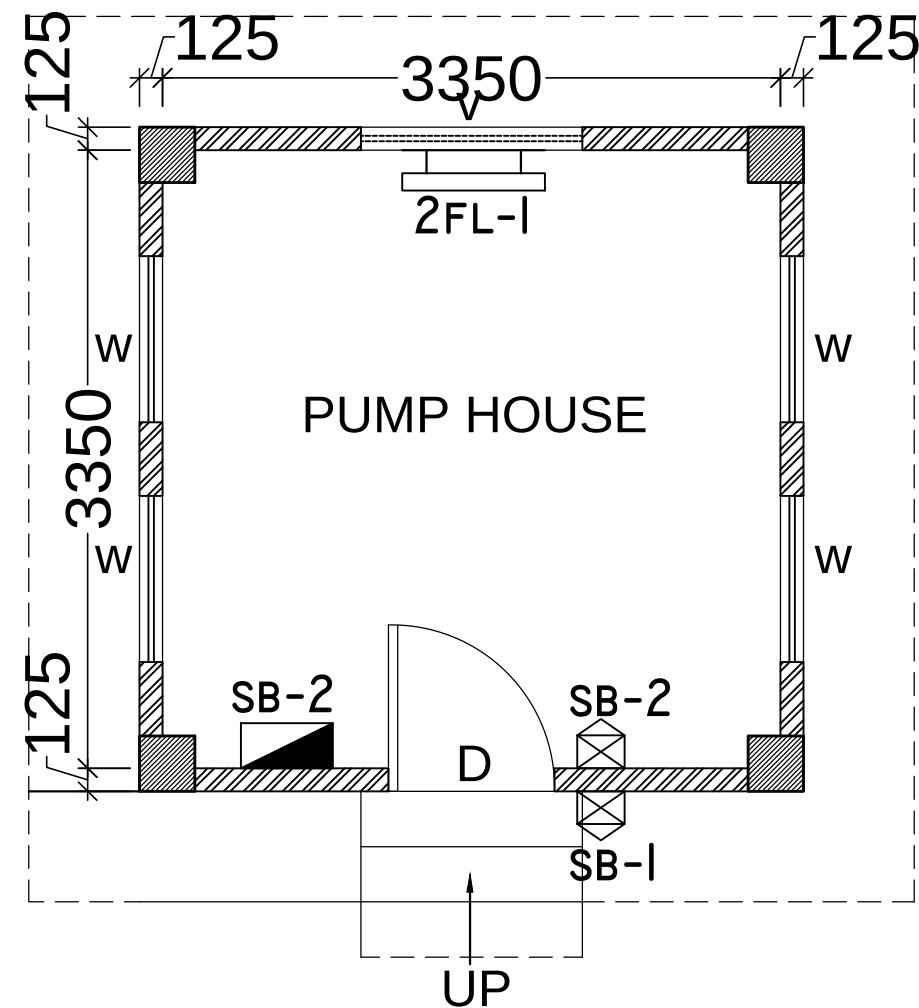

ELECTRICAL LAYOUT

Sl.No.	PARTICULAR	SYMBOL
1)	Distribution Board	
2)	Tube Light (Wall) (1X36 W)	
3)	Switch Board	
4)	Bulk Head Light	

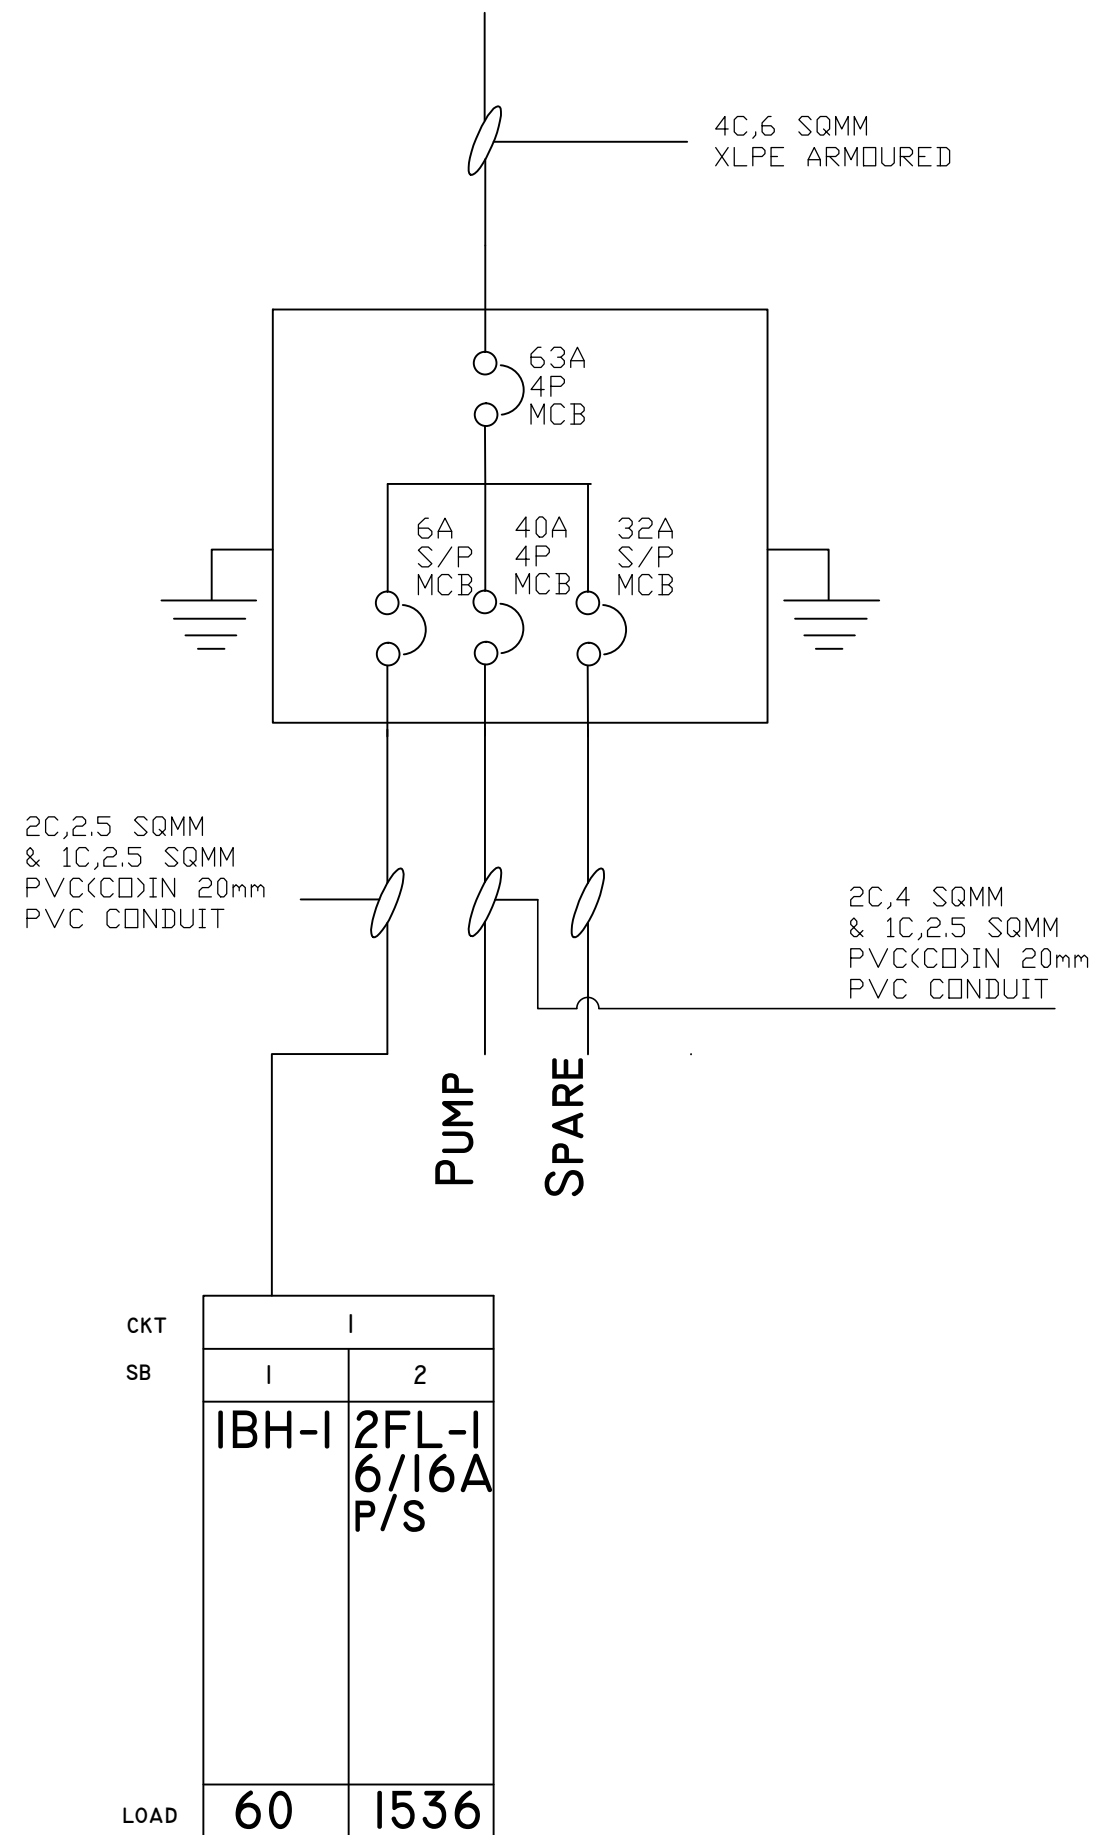

ELECTRICAL SLD

THIS DRAWING IS A COPYRIGHT.
CONTENTS OF THE DRAWING OR PART
THEREOF MAY NOT BE USED OR
REPRODUCED WITHOUT THE PERMISSION
OF THE **RAJKHOWAS AARCHI**
M.D.ROAD, CHANDMARI, GUWAHATI.

NOTES

1. ALL DIMENSIONS ARE TO BE READ AND NOT TO BE MEASURED.
2. ALL DIMENSIONS ARE IN MILLIMETER (MM) UNLESS OTHERWISE SPECIFIED.

S.NO.	REVISIONS	DATE
3		
2		
1		

REVISIONS

CLIENT

**BRAHMAPUTRA CRACKER
AND POLYMER LIMITED**

PROJECT

**PROPOSED PUMP HOUSE FOR
BCPL TOWNSHIP AT
LEPETKATA, DIBRUGARH.**

PUMP HOUSE


SCALE	JOB NO.	15/GU/2009
1:250	DEALT BY	
	CHECKED BY	

CLIENT'S SIGN

ARCHITECT'S SIGN

CONSULTANT

 ARCHITECTS, ENGINEERS,
VALUERS & PLANNERS
M.D.ROAD, CHANDMARI,
GUWAHATI-781003



DRAWING TITLE

**Electrical Layout & Electrical
SLD Of Pump House**

DRAWING NO.

RAA / BCPL/Pump House /T/ELEC-01