



NOTE: HALOGEN LAMP SHOULD BE PLACED AT FOUR CORNERS OD THE BUILDING.

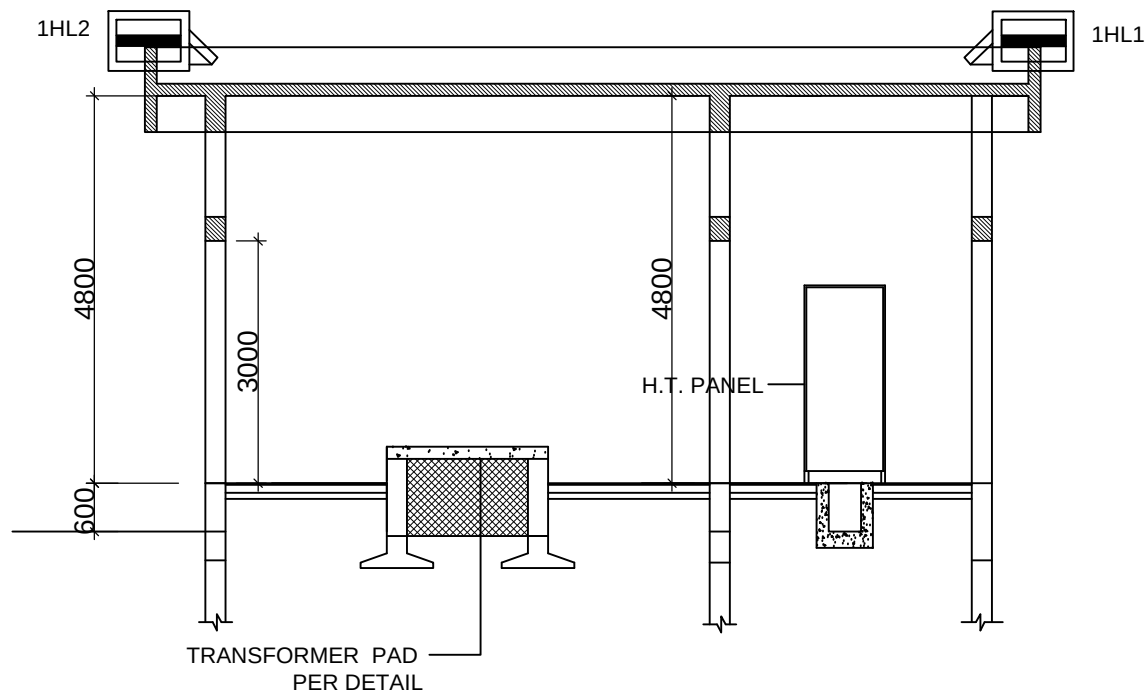

SECTION B-B

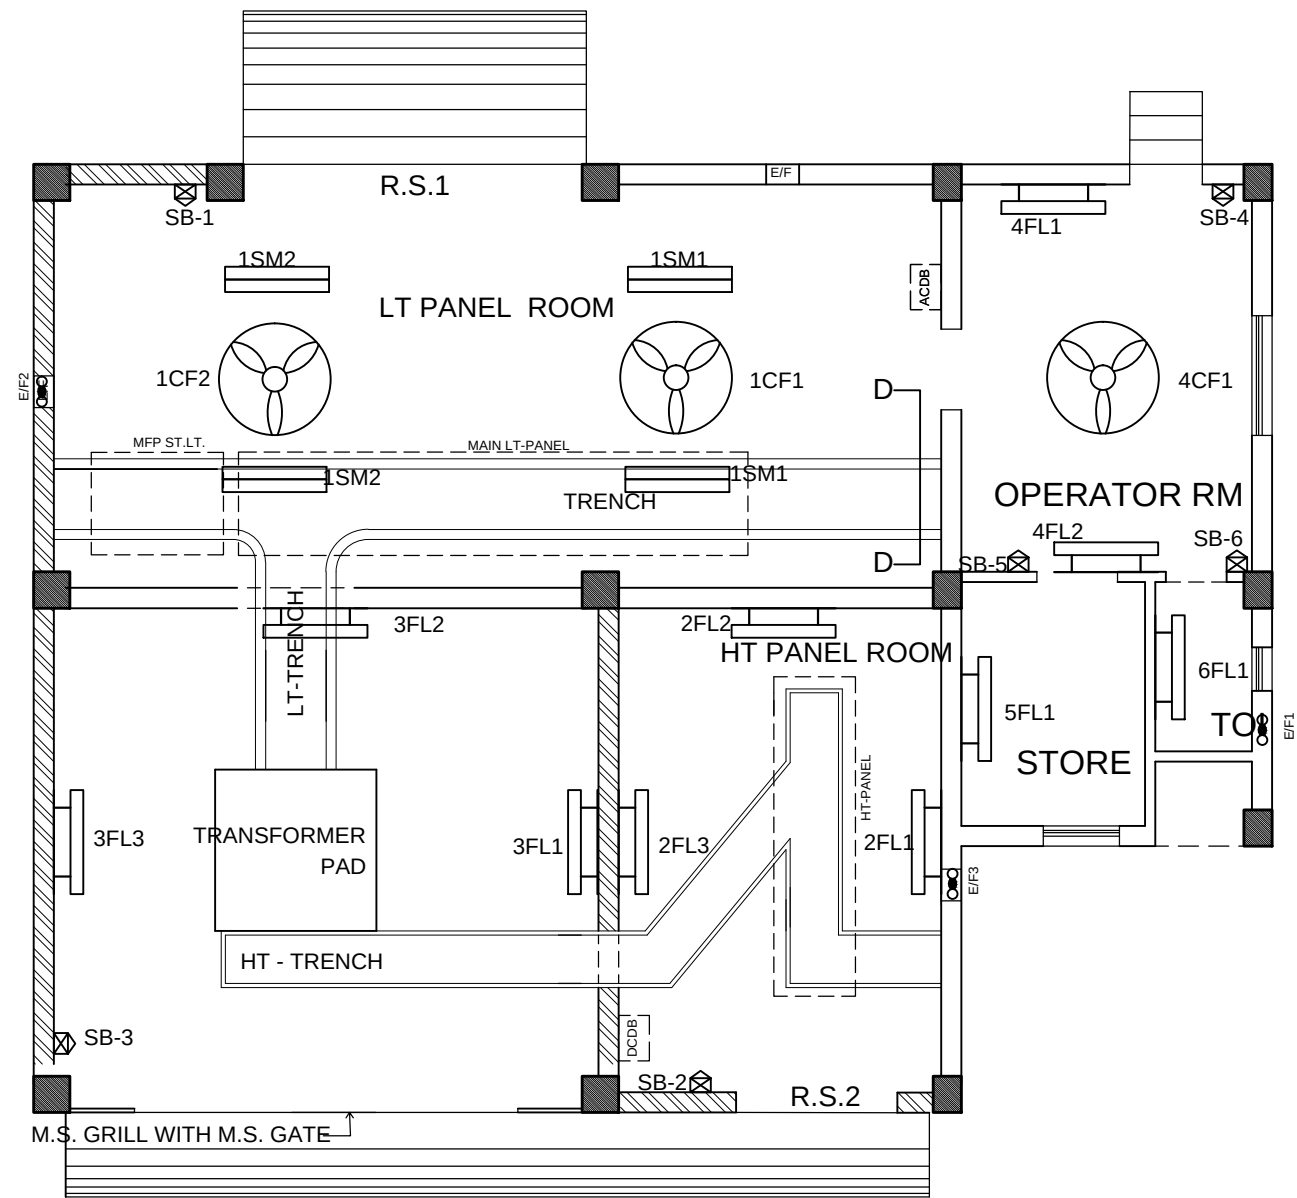

PLAN

Sl.No.	PARTICULAR	SYMBOL
1)	Distribution Board	
2)	Tube Light (Surface) (2X36 W)	
3)	Tube Light (Wall) (1X36 W)	
4)	Switch Board	
5)	Ceiling Fan	
6)	Exhaust Fan	
10)	Halogen Lamp	

THIS DRAWING IS A COPYRIGHT.
CONTENTS OF THE DRAWING OR PART THEREOF
MAY NOT BE USED OR REPRODUCED WITHOUT
THE PERMISSION OF RAJKHOWAS AARCHI
M.D ROAD, CHANDMARI, GUWAHATI.

NOTES

HT-PANEL SIZE : 2.5M X 2M X 1.5M (LXBXH)
LT-PANEL SIZE : 3.2M X 0.6M X 1.5M (LXBXH)
MFP S.T.L.T SIZE : 0.5M X 0.3M X 0.5M (LXBXH)
NOTE : SIZES OF THE PANELS ARE TENTATIVE.
AS PER REQUIREMENT IT MAY CHANGE.

S.NO.	REVISIONS	DATE
-------	-----------	------

REVISIONS

CLIENT

BRAHMAPUTRA CRACKER AND
POLYMER LIMITED

PROJECT

PROPOSED SUBSTATION AT
CISF TOWNSHIP,
LEPETKATA, DIBRUGARH.

SCALE : 1:100	JOB NO I5/GU/2009
DEALT BY	
CHECKED BY	

CLIENT'S SIGN

ARCHITECT'S SIGN

CONSULTANT

ARCHITECTS, ENGINEERS,
VALUERS & PLANNERS
M.D. ROAD, CHANDMARI
GUWAHATI-781003



DRAWING TITLE

ELECTRICAL LAYOUT OF PANEL ROOM

DRAWING NO.

RAA / CISF / SUBSTATION/T/ ELEC-01