



NOTE: HALOGEN LAMP SHOULD BE PLACED AT FOUR CORNERS OF THE BUILDING.

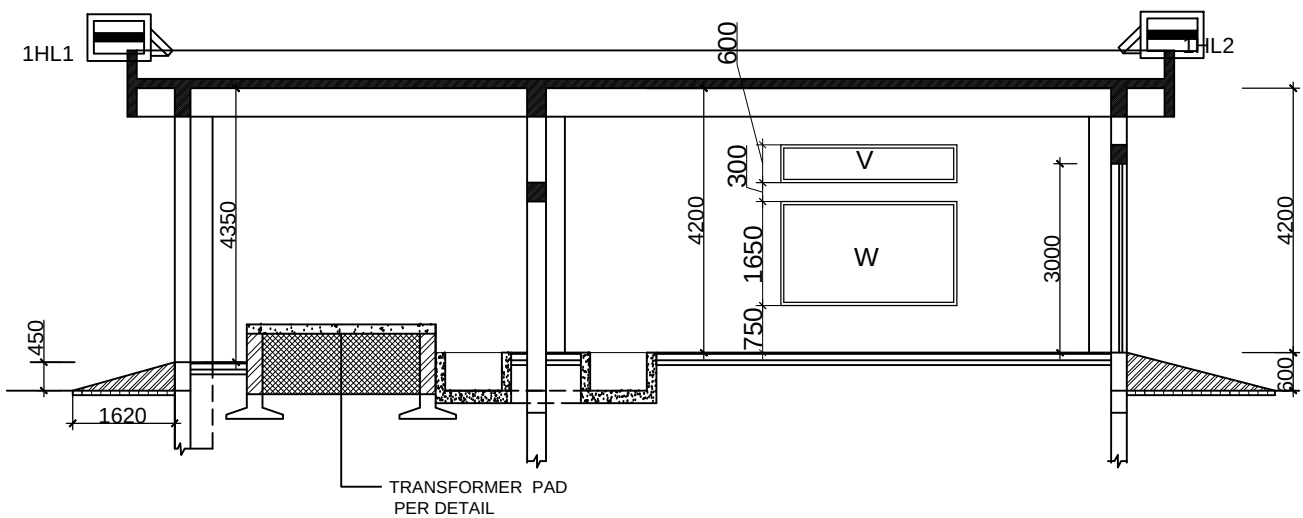

SECTION A-A

Sl.No.	PARTICULAR	SYMBOL
1)	Distribution Board	
2)	Tube Light (Surface) (2X36 W)	
3)	Tube Light (Wall) (1X36 W)	
4)	Switch Board	
5)	Ceiling Fan	
6)	Exhaust Fan	
10)	Halogen Lamp	

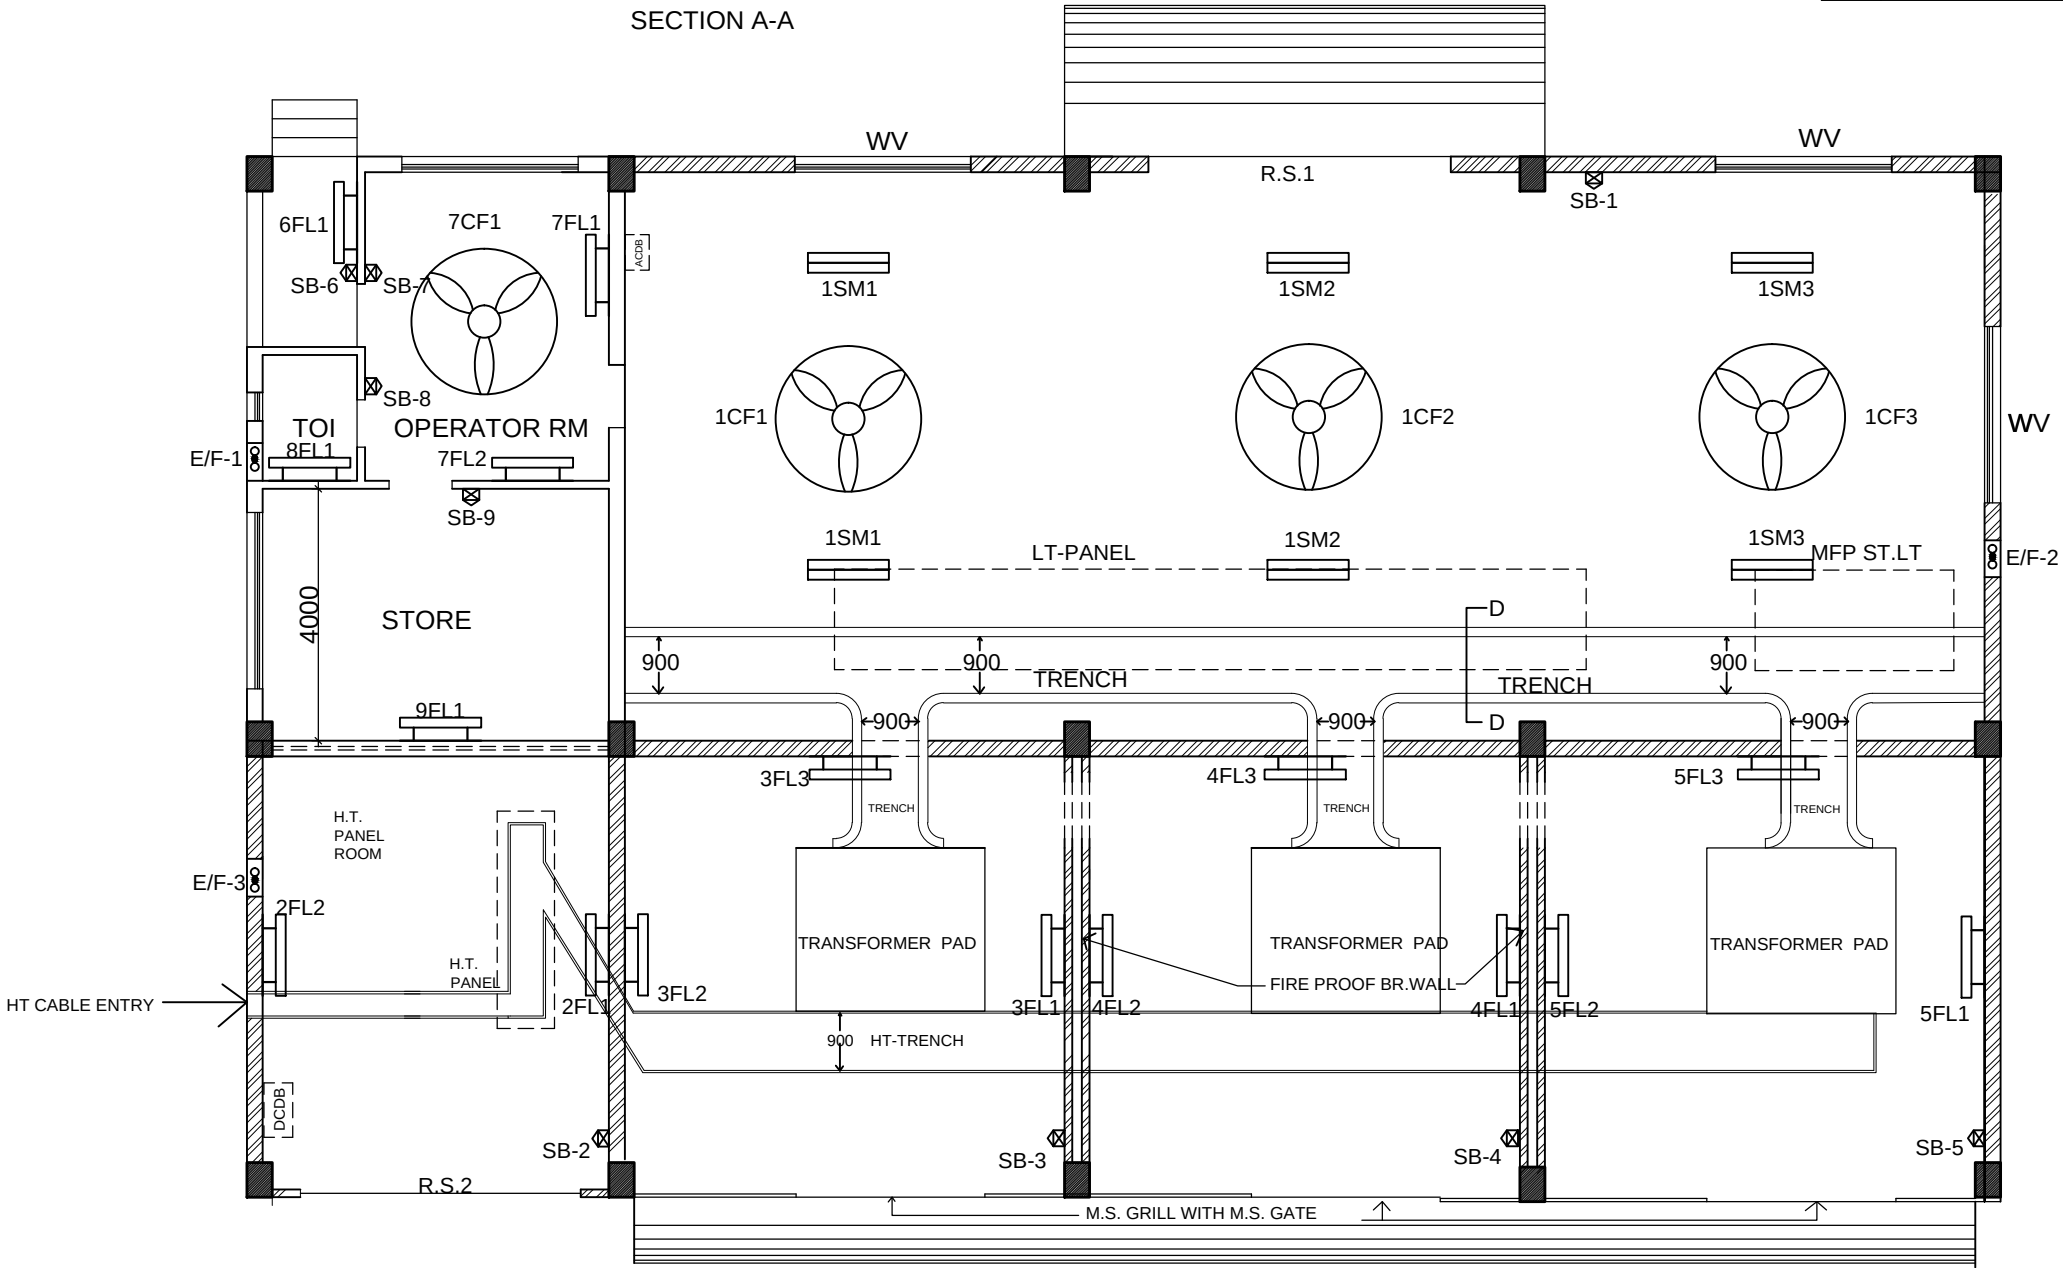

PLAN

THIS DRAWING IS A COPYRIGHT.
CONTENTS OF THE DRAWING OR PART THEREOF
MAY NOT BE USED OR REPRODUCED WITHOUT
THE PERMISSION OF RAJKHOWAS AARCHI
M.D ROAD,CHANDMARI, GUWAHATI.

NOTES

HT-PANEL SIZE : 4M x 2M x 2.5M (LxBxH)
LT-PANEL SIZE : 14M x 1.5M x 2M (LxBxH)

S.NO.	REVISIONS	DATE

REVISIONS

CLIENT

BRAHMAPUTRA CRACKER AND
POLYMER LIMITED

PROJECT

PROPOSED SUBSTATION OF
BCPL TOWNSHIP,
LEPETKATA,DIBRUGARH.

SCALE :	JOB NO	15/GU/2009
	DEALT BY	
	CHECKED BY	

CLIENT'S SIGN

ARCHITECT'S SIGN

CONSULTANT

ARCHITECTS, ENGINEERS,
VALUERS & PLANNERS
M.D. ROAD, CHANDMARI
GUWAHATI-781003

RAJKHOWAS
AARCHI

DRAWING TITLE

ELECTRICAL LAYOUT OF PANEL ROOM

DRAWING NO.

RAA / BCPL / SUBSTATION/ T/ELEC-01