


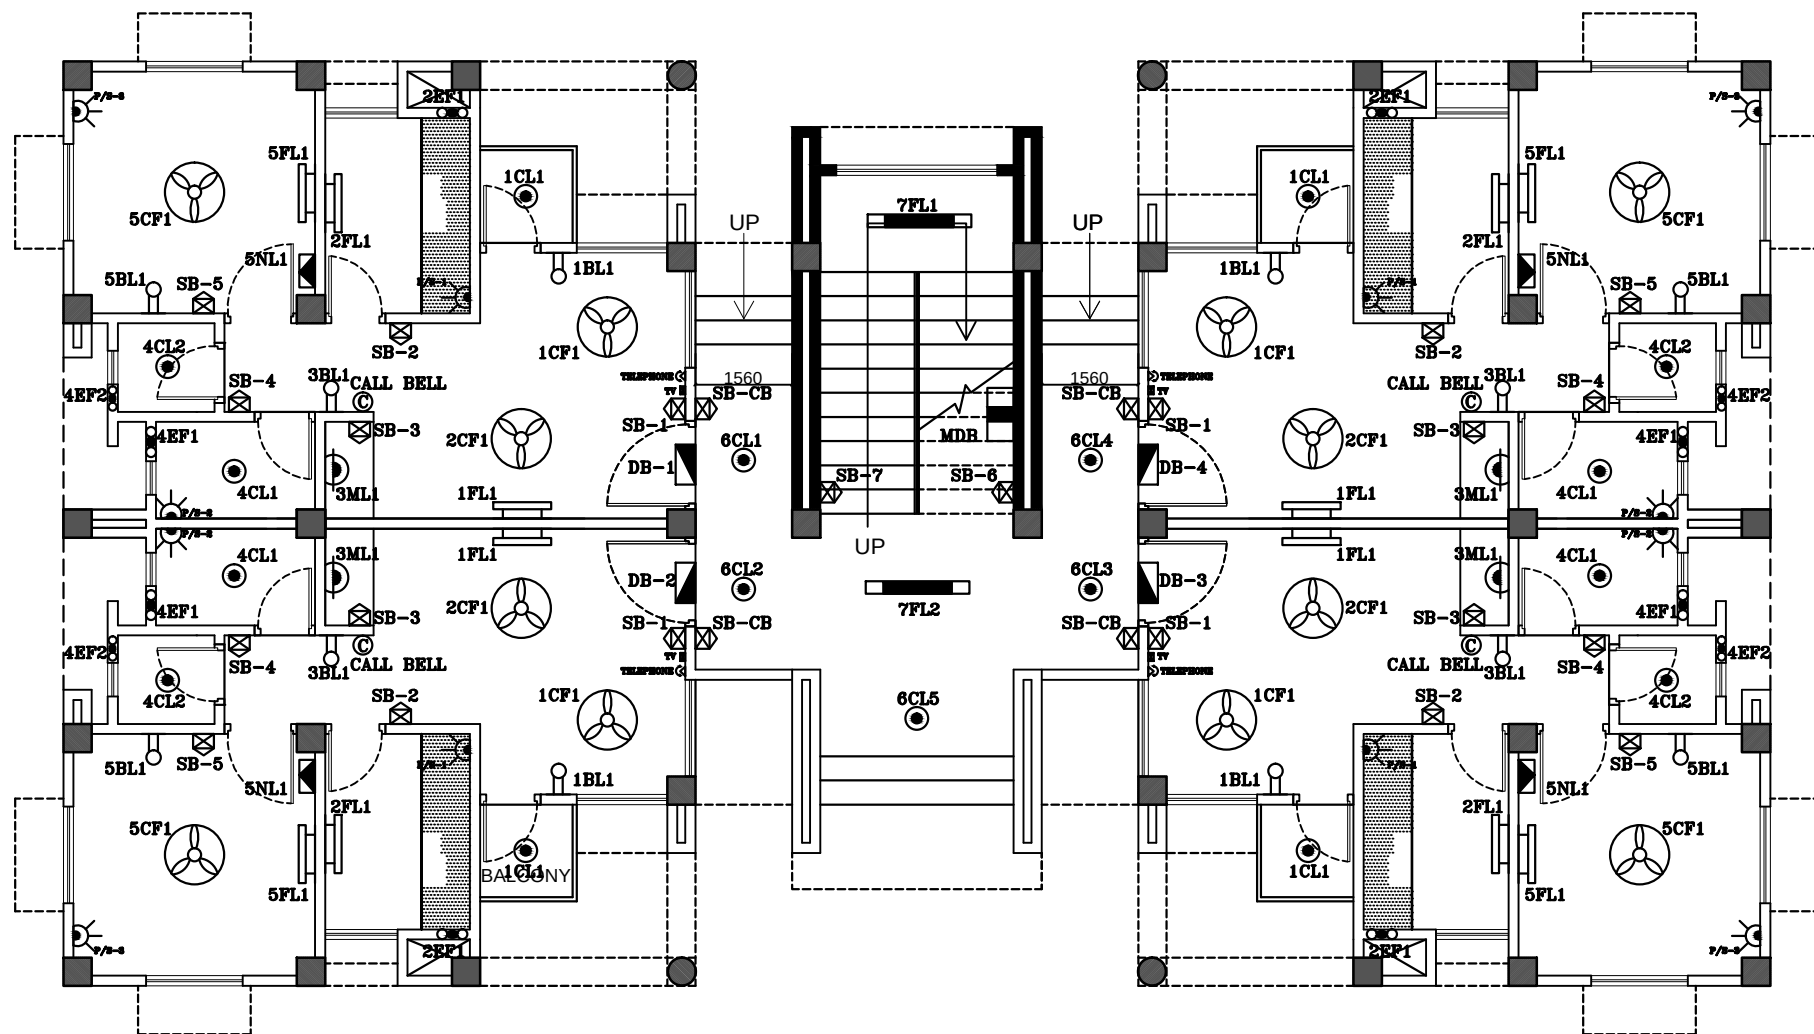

GROUND FLOOR ELECTRICAL PLAN

LEGENDS

Sl.No.	PARTICULAR	SYMBOL
1)	Distribution Board	
2)	Main Distribution Board	
3)	M.C.B	
4)	Ceiling Fan	
5)	Exhaust Fan	
6)	Wall Bracket	
7)	6/16 Amp plug pt.	
8)	Tube Light (Wall) (1X36 W)	
9)	Tube Light (Surface) (1X36 W)	
10)	Call Bell	
11)	Telephone point	
12)	Switch Board	
13)	Night Lamp	
14)	Ceiling Lamp (Surface)	
15)	Television Point	
16)	MCCB	
17)	Mirror Light	

THIS DRAWING IS A COPYRIGHT.
CONTENTS OF THE DRAWING OR PART
THEREOF MAY NOT BE USED OR
REPRODUCED WITHOUT THE PERMISSION
OF THE RAJKHOWAS AARCHI
M.D.ROAD, CHANDMARI, GUWAHATI.

NOTES

1. ALL DIMENSIONS ARE TO BE READ
AND NOT TO BE MEASURED.
2. ALL DIMENSIONS ARE IN
MILLIMETER(MM) UNLESS OTHERWISE
SPECIFIED.

S.NO. REVISIONS DATE

REVISIONS

CLIENT

BRAHMAPUTRA CRACKER
AND POLYMER LIMITED

PROJECT

PROPOSED CONSTRUCTION OF
ADDITIONAL INFRASTRUCTURE
AT CISF TOWNSHIP

TYPE-A QUARTERS

SCALE

JOB NO.

DEALT BY

CHECKED BY

CLIENT'S SIGN

ARCHITECT'S SIGN

CONSULTANT

ARCHITECTS, ENGINEERS,
VALUERS & PLANNERS
M.D.ROAD, CHANDMARI,
GUWAHATI-781003



DRAWING TITLE

GROUND FLOOR
ELECTRICAL LAYOUT PLAN
OF A-TYPE QUARTERS

DRAWING NO.

RAA / CISF/ TYPE-A /T/ELEC- 03(A)