

LEGENDS

Sl.No.	PARTICULAR	SYMBOL
1)	Distribution Board	
2)	Main Distribution Board	
3)	M.C.B	
4)	Ceiling Fan	
5)	Exhaust Fan	
6)	Wall Bracket	
7)	6/16 Amp plug pt.	
8)	Tube Light (Wall) (1X36 W)	
9)	Tube Light (Surface) (1X36 W)	
10)	Call Bell	
11)	Telephone point	
12)	Switch Board	
13)	Night Lamp	
14)	Ceiling Lamp (Surface)	
15)	Television Point	
16)	MCCB	
17)	Mirror Light	

THIS DRAWING IS A COPYRIGHT.
CONTENTS OF THE DRAWING OR PART
THEREOF MAY NOT BE USED OR
REPRODUCED WITHOUT THE PERMISSION
OF THE RAJKHOWAS AARCHI
M.D.ROAD, CHANDMARI, GUWAHATI.

NOTES

1. ALL DIMENSIONS ARE TO BE READ
AND NOT TO BE MEASURED.
2. ALL DIMENSIONS ARE IN
MILLIMETER(MM) UNLESS OTHERWISE
SPECIFIED.

02	02	21.03.2013
01	01	15.03.2013
S.NO.	REVISIONS	DATE

REVISIONS

CLIENT

BRAHMAPUTRA CRACKER
AND POLYMER LIMITED

PROJECT

PROPOSED CONSTRUCTION OF
ADDITIONAL INFRASTRUCTURE
AT CISF TOWNSHIP

TYPE-B QUARTERS

SCALE	JOB NO.	
	DEALT BY	
	CHECKED BY	

CLIENT'S SIGN

ARCHITECT'S SIGN

CONSULTANT

ARCHITECTS, ENGINEERS,
VALUERS & PLANNERS
M.D.ROAD, CHANDMARI,
GUWAHATI-781003




DRAWING TITLE

FIRST FLOOR
ELECTRICAL LAYOUT PLAN
OF B-TYPE QUARTERS

DRAWING NO.

RAA / CISF/ TYPE-B /T/ELEC-01(B)

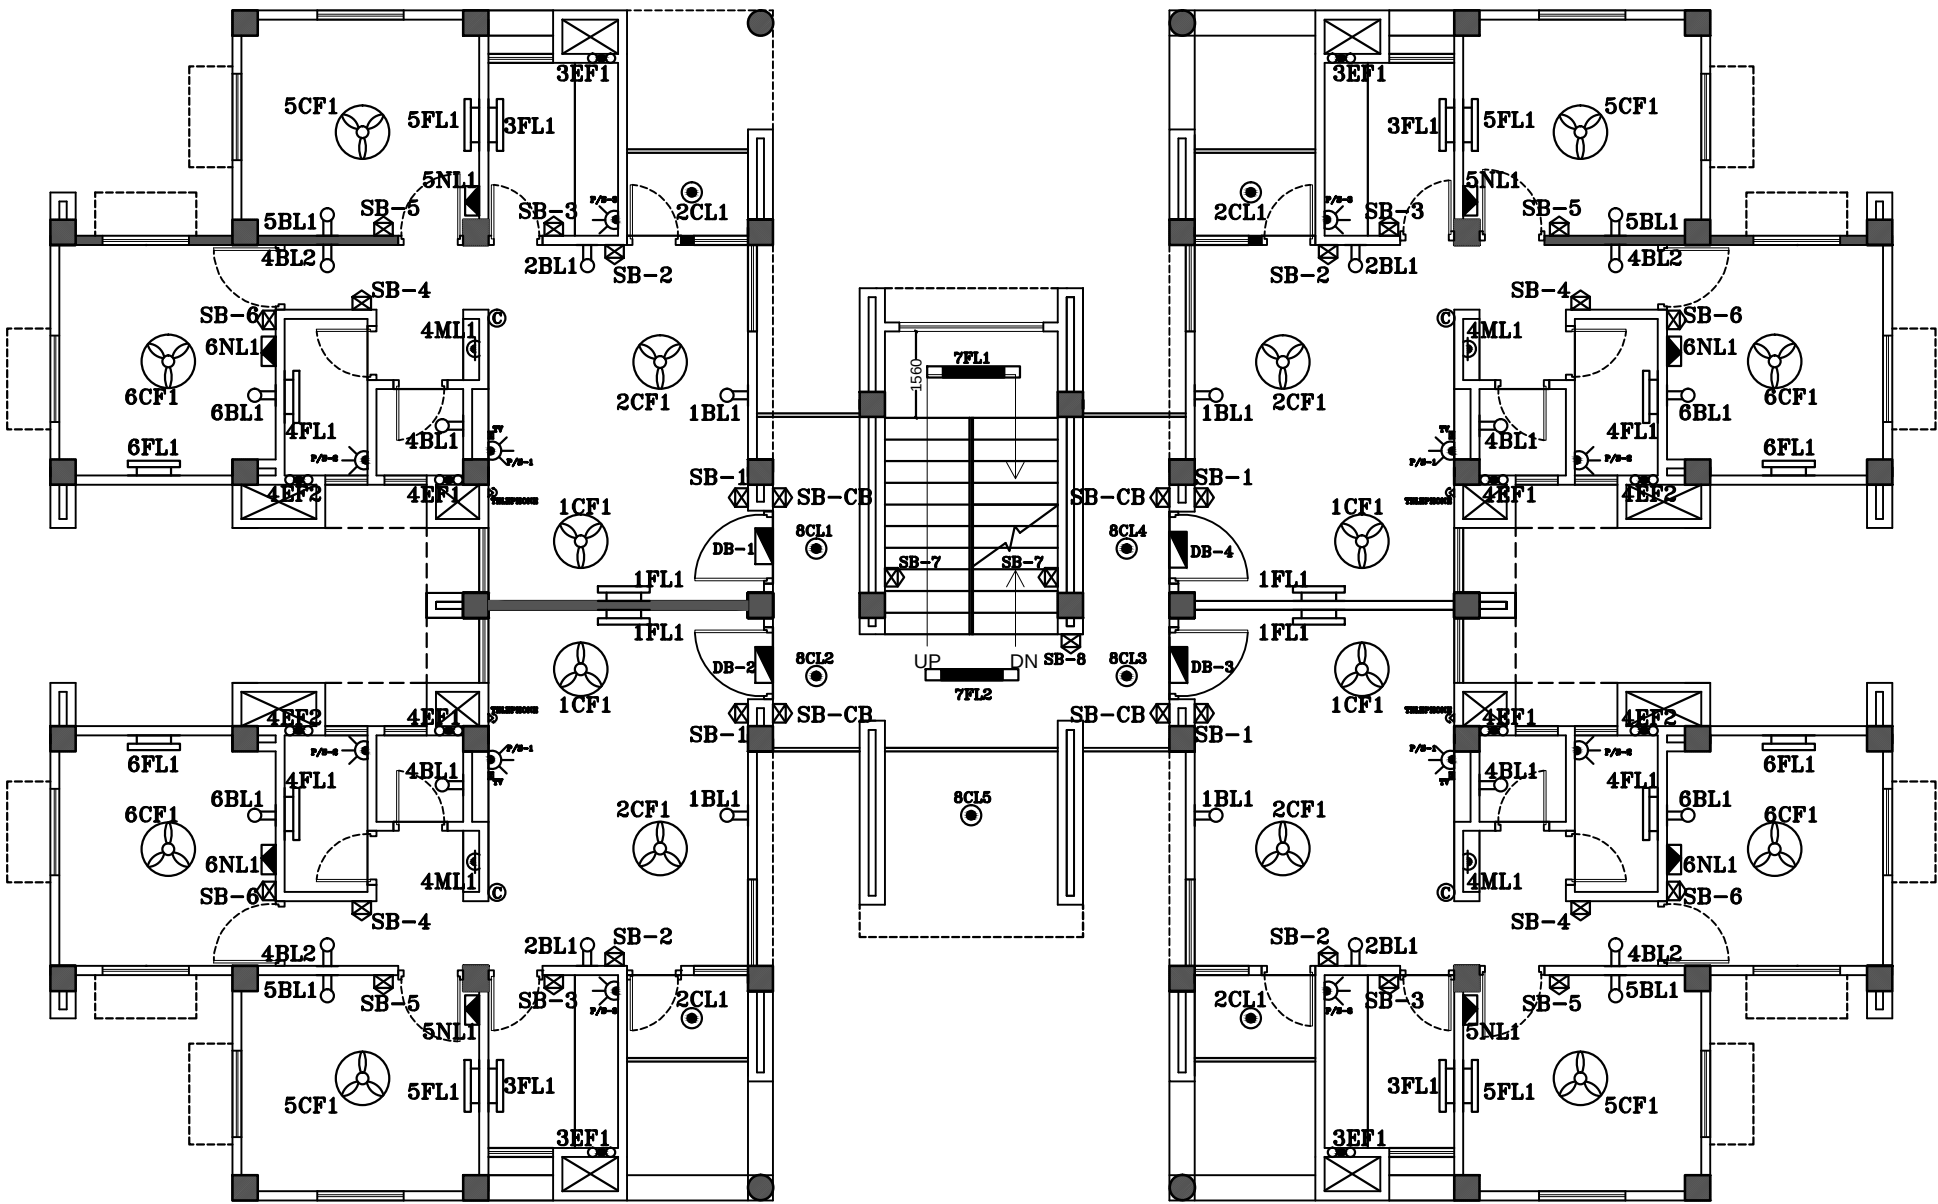

FIRST FLOOR ELCTRICAL PLAN