


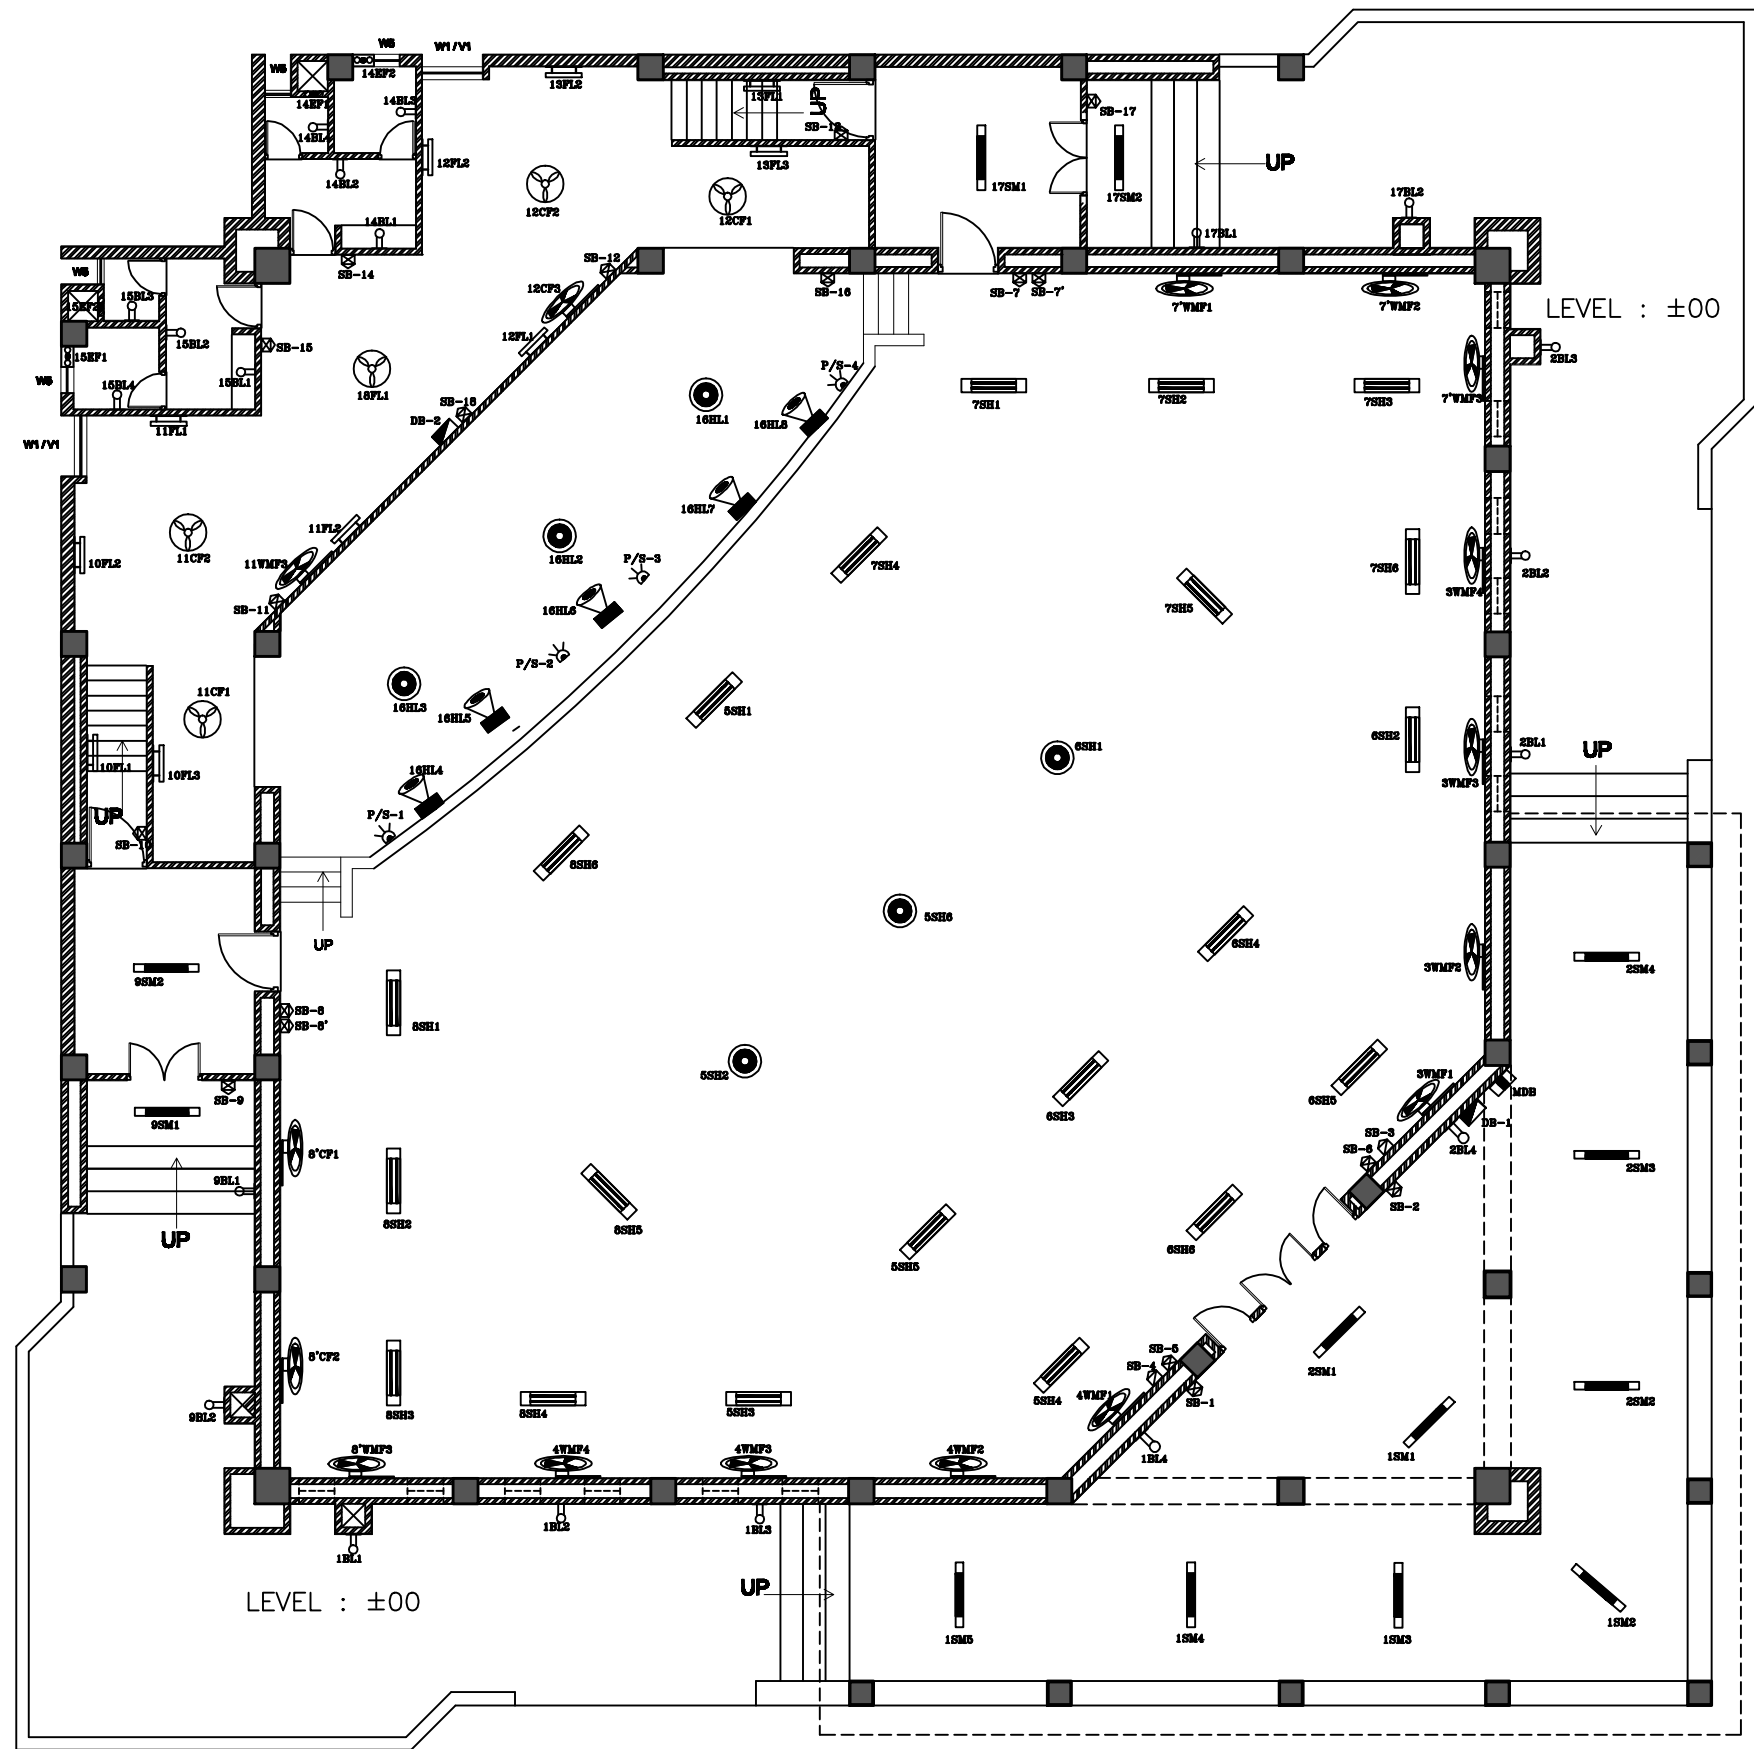

ELECTRICAL LAYOUT PLAN

LEGENDS

Sl.No.	PARTICULAR	SYMBOL
1)	Distribution Board	
2)	Main Distribution Board	
3)	M.C.B	
4)	Ceiling Fan	
5)	Exhaust Fan	
6)	Wall Bracket	
7)	6/16 Amp plug pt.	
8)	Tube Light (Wall) (1X36 W)	
9)	Tube Light (Surface) (1X36 W)	
10)	Hanging round halogen lamp	
11)	Hanging double tube fitting	
12)	Switch Board	
13)	MCCB	
14)	RCBO	
15)	Wall Mounted Fan	
16)	Focusing Halogen Lamp	

THIS DRAWING IS A COPYRIGHT.
CONTENTS OF THE DRAWING OR PART
THEREOF MAY NOT BE USED OR
REPRODUCED WITHOUT THE PERMISSION
OF THE RAJKHOWAS AARCHI
M.D.ROAD, CHANDMARI, GUWAHATI.

NOTES

1. ALL DIMENSIONS ARE TO BE READ AND NOT TO BE MEASURED.
2. ALL DIMENSIONS ARE IN MILLIMETER(MM) UNLESS OTHERWISE SPECIFIED.
3. ALL THE HANGING LIGHTS AND CEILING FAN SHOULD BE HANGED WITH SUITABLE SIZE IRON ROD.

S.NO.	REVISIONS	DATE
01	01	16.08.2018

REVISIONS

CLIENT

BRAHMAPUTRA CRACKER
AND POLYMER LIMITED

PROJECT

PROPOSED CONSTRUCTION OF
ADDITIONAL INFRASTRUCTURE
AT CISF TOWNSHIP

RECREATION ROOM


SCALE	JOB NO.
	DEALT BY
	CHECKED BY

CLIENT'S SIGN

ARCHITECT'S SIGN

CONSULTANT

 ARCHITECTS, ENGINEERS,
VALUERS & PLANNERS
M.D.ROAD, CHANDMARI,
GUWAHATI-781003



DRAWING TITLE

ELECTRICAL LAYOUT PLAN
OF RECREATION ROOM

DRAWING NO.

RAA / CISF/ RECREATION ROOM /TELEC-01