


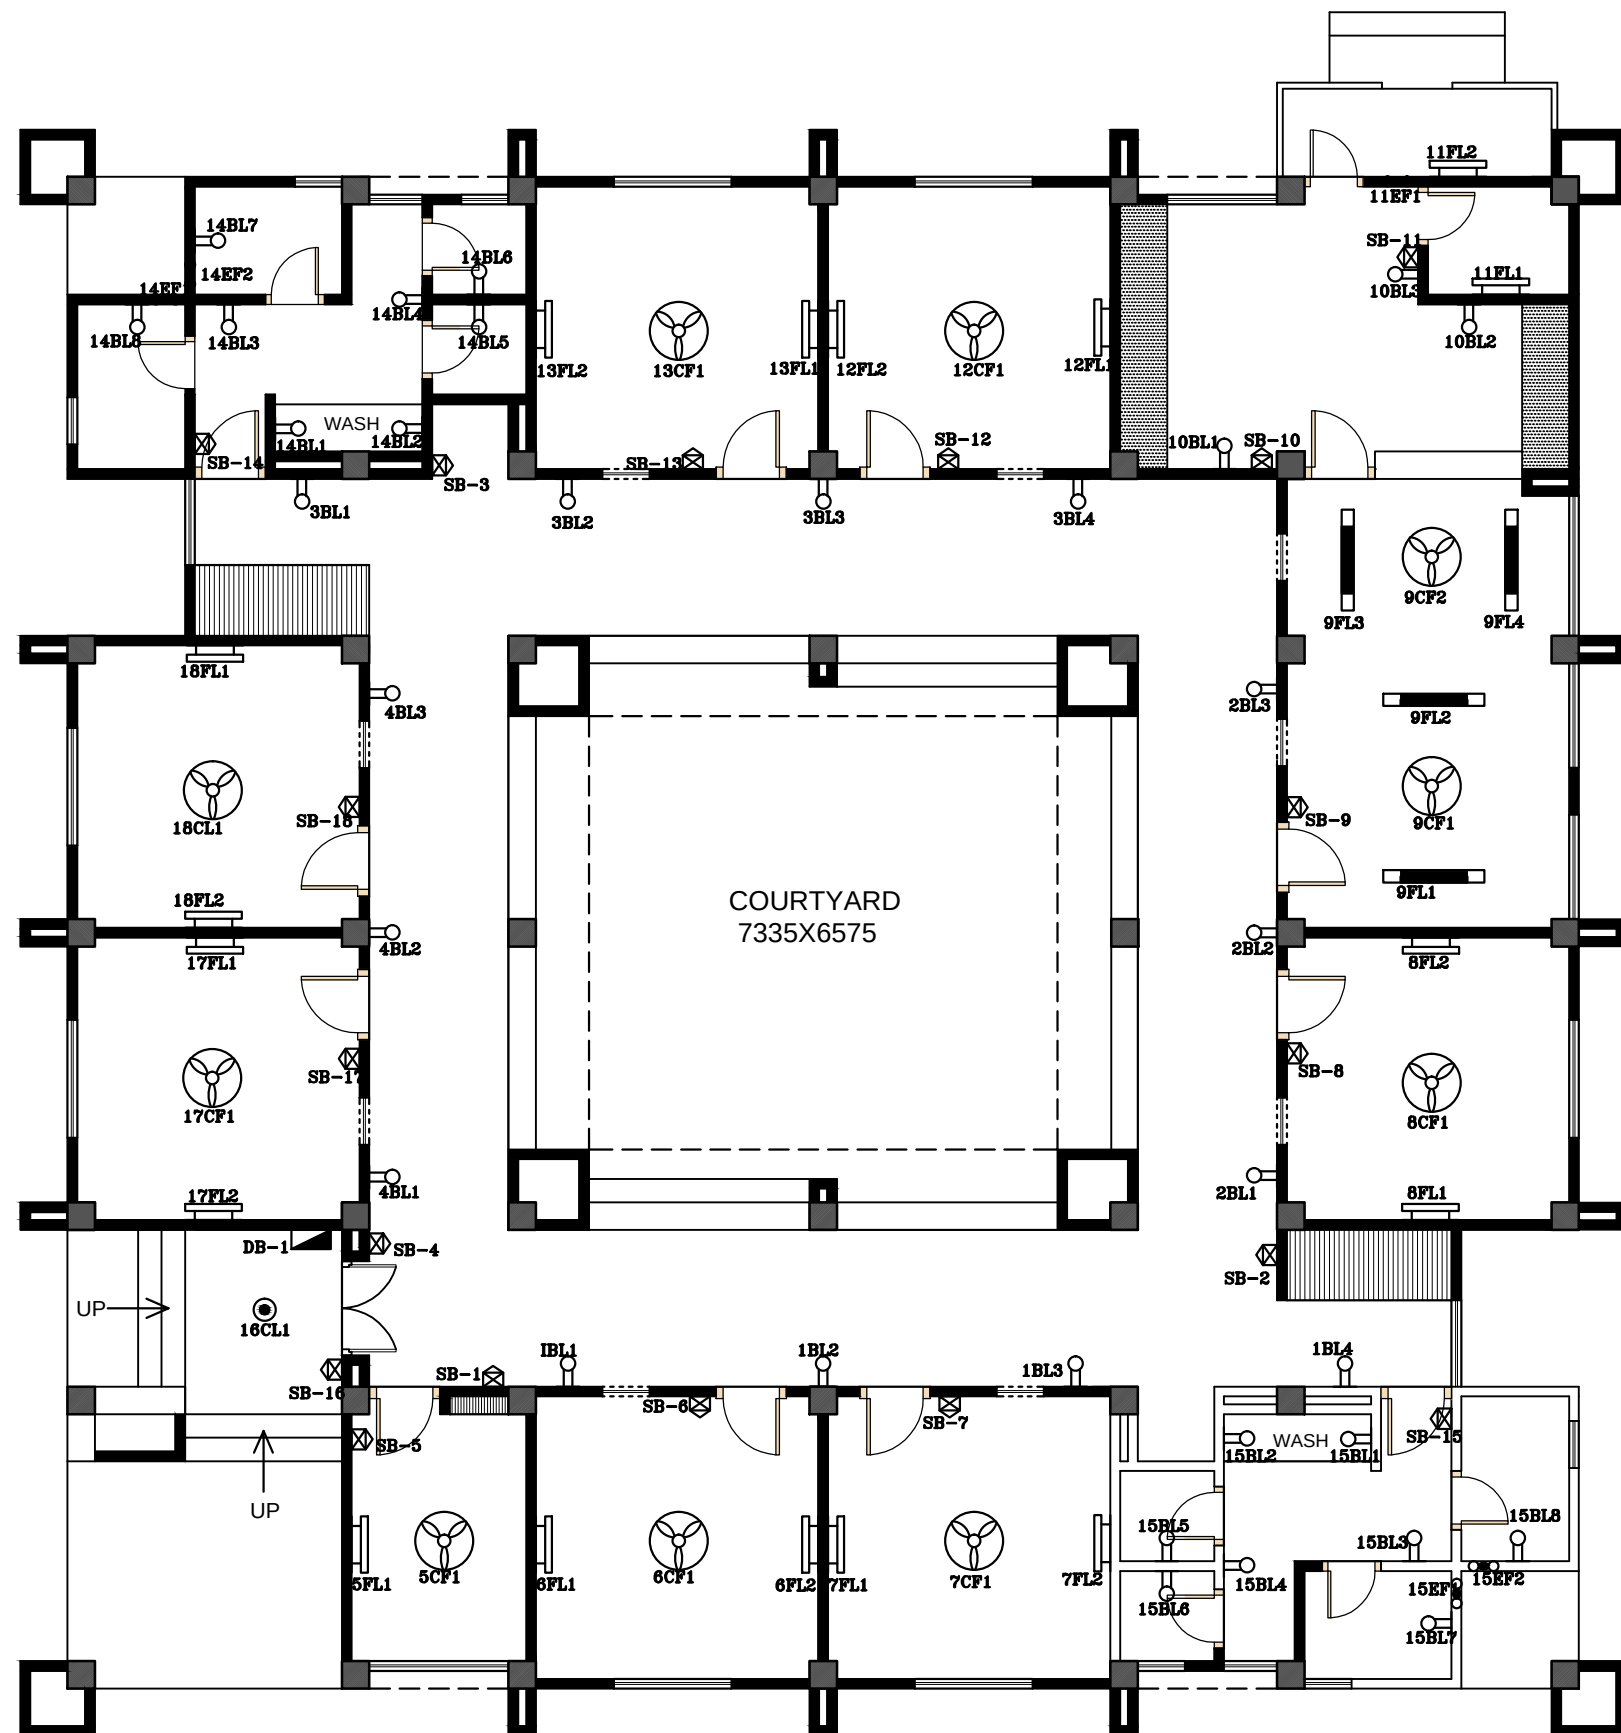

ELECTRICAL LAYOUT PLAN

LEGENDS

Sl.No.	PARTICULAR	SYMBOL
1)	Distribution Board	
2)	Main Distribution Board	
3)	M.C.B	
4)	Ceiling Fan	
5)	Exhaust Fan	
6)	Wall Bracket	
7)	6/16 Amp plug pt.	
8)	Tube Light (Wall) (1X36 W)	
9)	Tube Light (Surface) (1X36 W)	
10)	Switch Board	

THIS DRAWING IS A COPYRIGHT.
CONTENTS OF THE DRAWING OR PART
THEREOF MAY NOT BE USED OR
REPRODUCED WITHOUT THE PERMISSION
OF THE RAJKHOWAS AARCHI
M.D.ROAD, CHANDMARI, GUWAHATI.

NOTES

1. ALL DIMENSIONS ARE TO BE READ
AND NOT TO BE MEASURED.
2. ALL DIMENSIONS ARE IN
MILLIMETER(MM) UNLESS OTHERWISE
SPECIFIED.

01	01	15.03.2013
S.NO.	REVISIONS	DATE

REVISIONS

CLIENT

BRAHMAPUTRA CRACKER
AND POLYMER LIMITED

PROJECT

PROPOSED CONSTRUCTION OF
ADDITIONAL INFRASTRUCTURE
AT CISF TOWNSHIP

S.O BARRACK FOR 14 NOS.
SUB-ORDINATE OFFICER

SCALE	JOB NO.	
	DEALT BY	
	CHECKED BY	

CLIENT'S SIGN

ARCHITECT'S SIGN

CONSULTANT

ARCHITECTS, ENGINEERS,
VALUERS & PLANNERS
M.D.ROAD, CHANDMARI,
GUWAHATI- 781003



DRAWING TITLE

ELECTRICAL LAYOUT
PLAN OF S.O.BARRACK

DRAWING NO.

RAA / CISF/S.O BARRACK /T/ELEC-01