


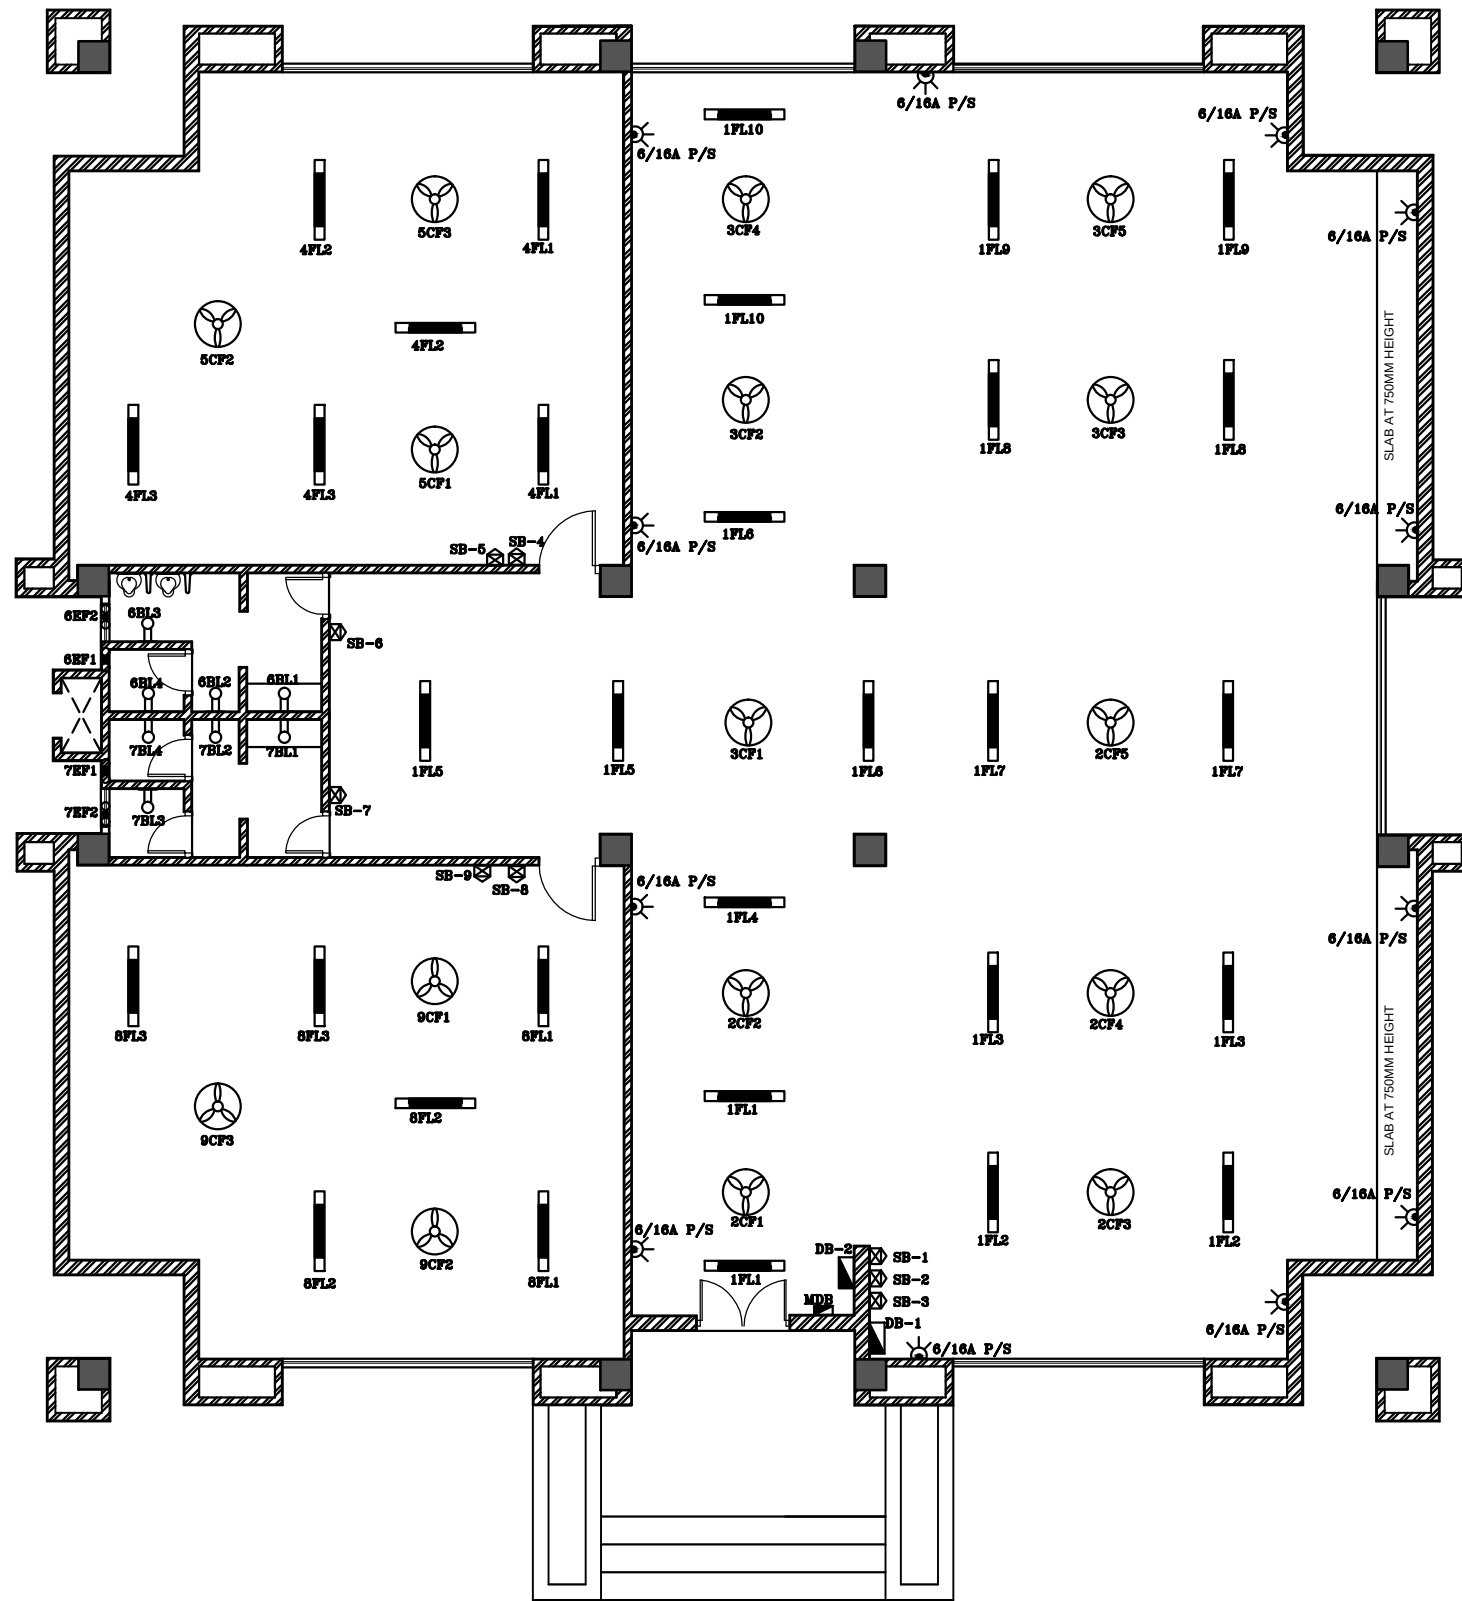

LEGENDS

Sl.No.	PARTICULAR	SYMBOL
1)	Distribution Board	
2)	Main Distribution Board	
3)	M.C.B	
4)	Ceiling Fan	
5)	Exhaust Fan	
6)	Wall Bracket	
7)	6/16 Amp plug pt.	
8)	Tube Light (Surface) (1X36 W)	
9)	Switch Board	

THIS DRAWING IS A COPYRIGHT.
CONTENTS OF THE DRAWING OR PART
THEREOF MAY NOT BE USED OR
REPRODUCED WITHOUT THE PERMISSION
OF THE RAJKHOWAS AARCHI
M.D.ROAD, CHANDMARI, GUWAHATI.

NOTES

1. ALL DIMENSIONS ARE TO BE READ
AND NOT TO BE MEASURED.
2. ALL DIMENSIONS ARE IN
MILLIMETER(MM) UNLESS OTHERWISE
SPECIFIED.
3. ALL THE 6/16 P/S SHOULD BE
INSTALLED 450MM ABOVE FINISH
FLOOR LEVEL

01	01	15.03.2013
S.NO.	REVISIONS	DATE

REVISIONS

CLIENT

BRAHMAPUTRA CRACKER
AND POLYMER LIMITED

PROJECT

PROPOSED CONSTRUCTION OF
ADDITIONAL INFRASTRUCTURE
AT CISF TOWNSHIP

STAFF WELFARE CENTRE

SCALE	JOB NO.	
	DEALT BY	
	CHECKED BY	

CLIENT'S SIGN

--

ARCHITECT'S SIGN

--

CONSULTANT

ARCHITECTS, ENGINEERS,
VALUERS & PLANNERS
M.D.ROAD, CHANDMARI,
GUWAHATI-781003

RAJKHOWAS
AARCHI

DRAWING TITLE

ELECTRICAL LAYOUT PLAN
OF STAFF WELFARE CENTRE

DRAWING NO.

RAA / CISF/ STAFF WELFARE CENTRE /T/ELEC-01